



KERRY PIKE PEDESTRIAN IMPROVEMENT SCHEME SECTION 38 PROPOSAL



Rev. Description **ISSUED FOR SECTION 38 PLANNING** 29.02.24

KERRY PIKE PEDESTRIAN IMPROVEMENT SCHEME	CLIENT		Comhairle Cathrach Chorcaí Cork City Council		
SHEET	Date	29.02.24	Project number P22-181	Scale (@ A1-) Scale N/A	
COVER SHEET	Drawn by	AQ	Drawing Number		Rev
	Checked by	PW	P22-181-0102-1001		Α
	D:\ACAD\2022\P22-1	181\P22-181-0102-10	001		

KERRY PIKE PEDESTRIAN IMPROVEMENT SCHEME SECTION 38 PROPOSAL


Drawing Index

Drawing Title	Drawing Number
COVER SHEET	P22-181-0102-1001
DRAWING INDEX	P22-181-0102-1002
SITE LOCATION PLAN	P22-181-0102-1003
SECTION 38 PROPOSAL - SHEET 1 0F 8	P22-181-0102-1004
SECTION 38 PROPOSAL - SHEET 2 OF 8	P22-181-0102-1005
SECTION 38 PROPOSAL - SHEET 3 OF 8	P22-181-0102-1006
SECTION 38 PROPOSAL - SHEET 4 OF 8	P22-181-0102-1007
SECTION 38 PROPOSAL - SHEET 5 OF 8	P22-181-0102-1008
SECTION 38 PROPOSAL - SHEET 6 OF 8	P22-181-0102-1009
SECTION 38 PROPOSAL - SHEET 7 OF 8	P22-181-0102-1010
SECTION 38 PROPOSAL - SHEET 8 OF 8	P22-181-0102-1011
TYPICAL CROSS SECTIONS	P22-181-0102-1012



Rev.	Description	Арр Ву	Date
Α	ISSUED FOR SECTION 38 PLANNING	GF	29.02.24

Date 29.02.24 Project number P22-181 Scale (@ A1-) Scale N/A	KERRY PIKE PEDESTRIAN IMPROVEMENT SCHEME			Comhairle Cathrach Chorcaí Cork City Council		
Checked by P22-181-0102-1002	SHEET	Date	29.02.24	Project number P22-181	Scale (@ A1-) Scale N/A	
Checked by PW P22-181-0102-1002 A	DRAWING INDEX	Drawn by	AQ			Rev
		Checked by	PW	P22-181-0102-1002		Α

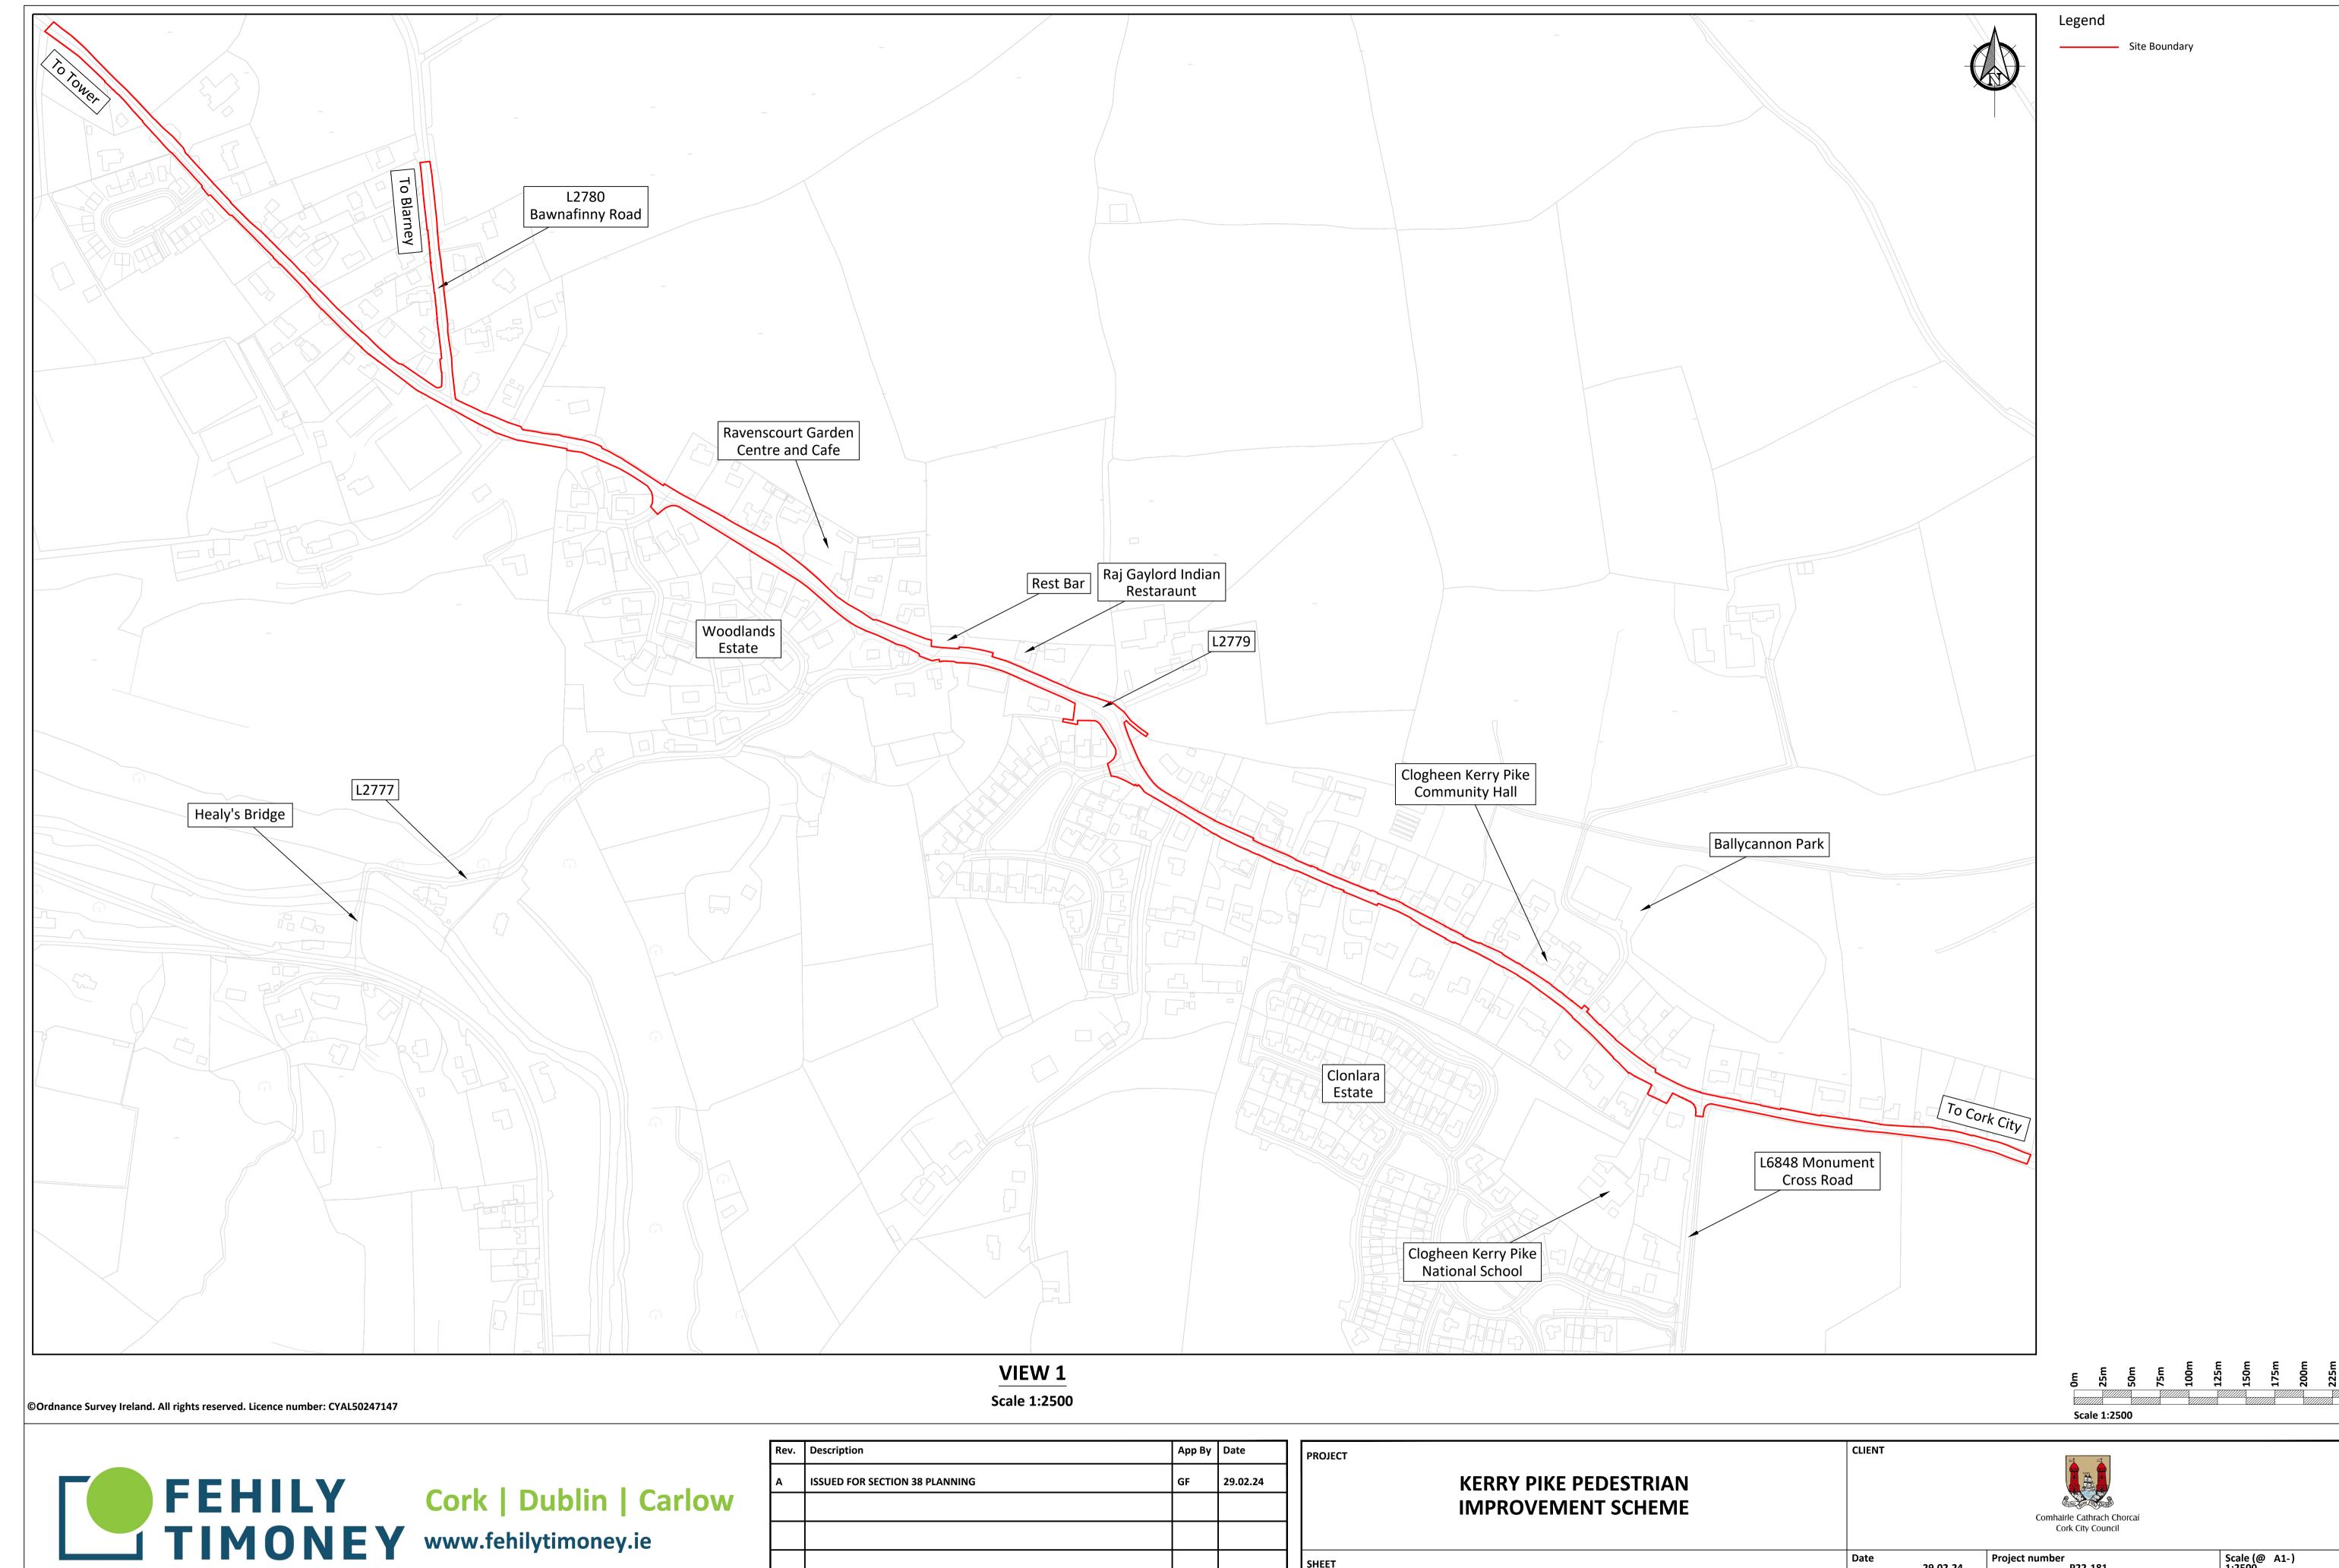





No part of this document may be reproduced or transmitted in any form or stored in any retrieval system of any nature without the written permission of Fehily Timoney & Company as copyright holder except as agreed for use on the project for which the document was originally issued. Do not scale. Use figured dimensions only. If in doubt - Ask!

Rev.	Description	Арр Ву	Date
Α	ISSUED FOR SECTION 38 PLANNING	GF	29.02.24

PROJECT	KERRY PIKE PEDESTRIAN IMPROVEMENT SCHEME	CLIENT Comhairle Cathrach Chorcaí Cork City Council	
SHEET		Date	@ A1-)
	SITE LOCATION PLAN	Drawn by AQ Drawing Number	Rev
		Checked by PW P22-181-0102-1003	A
		O:\ACAD\2022\P22-181\P22-181-0102-1003	

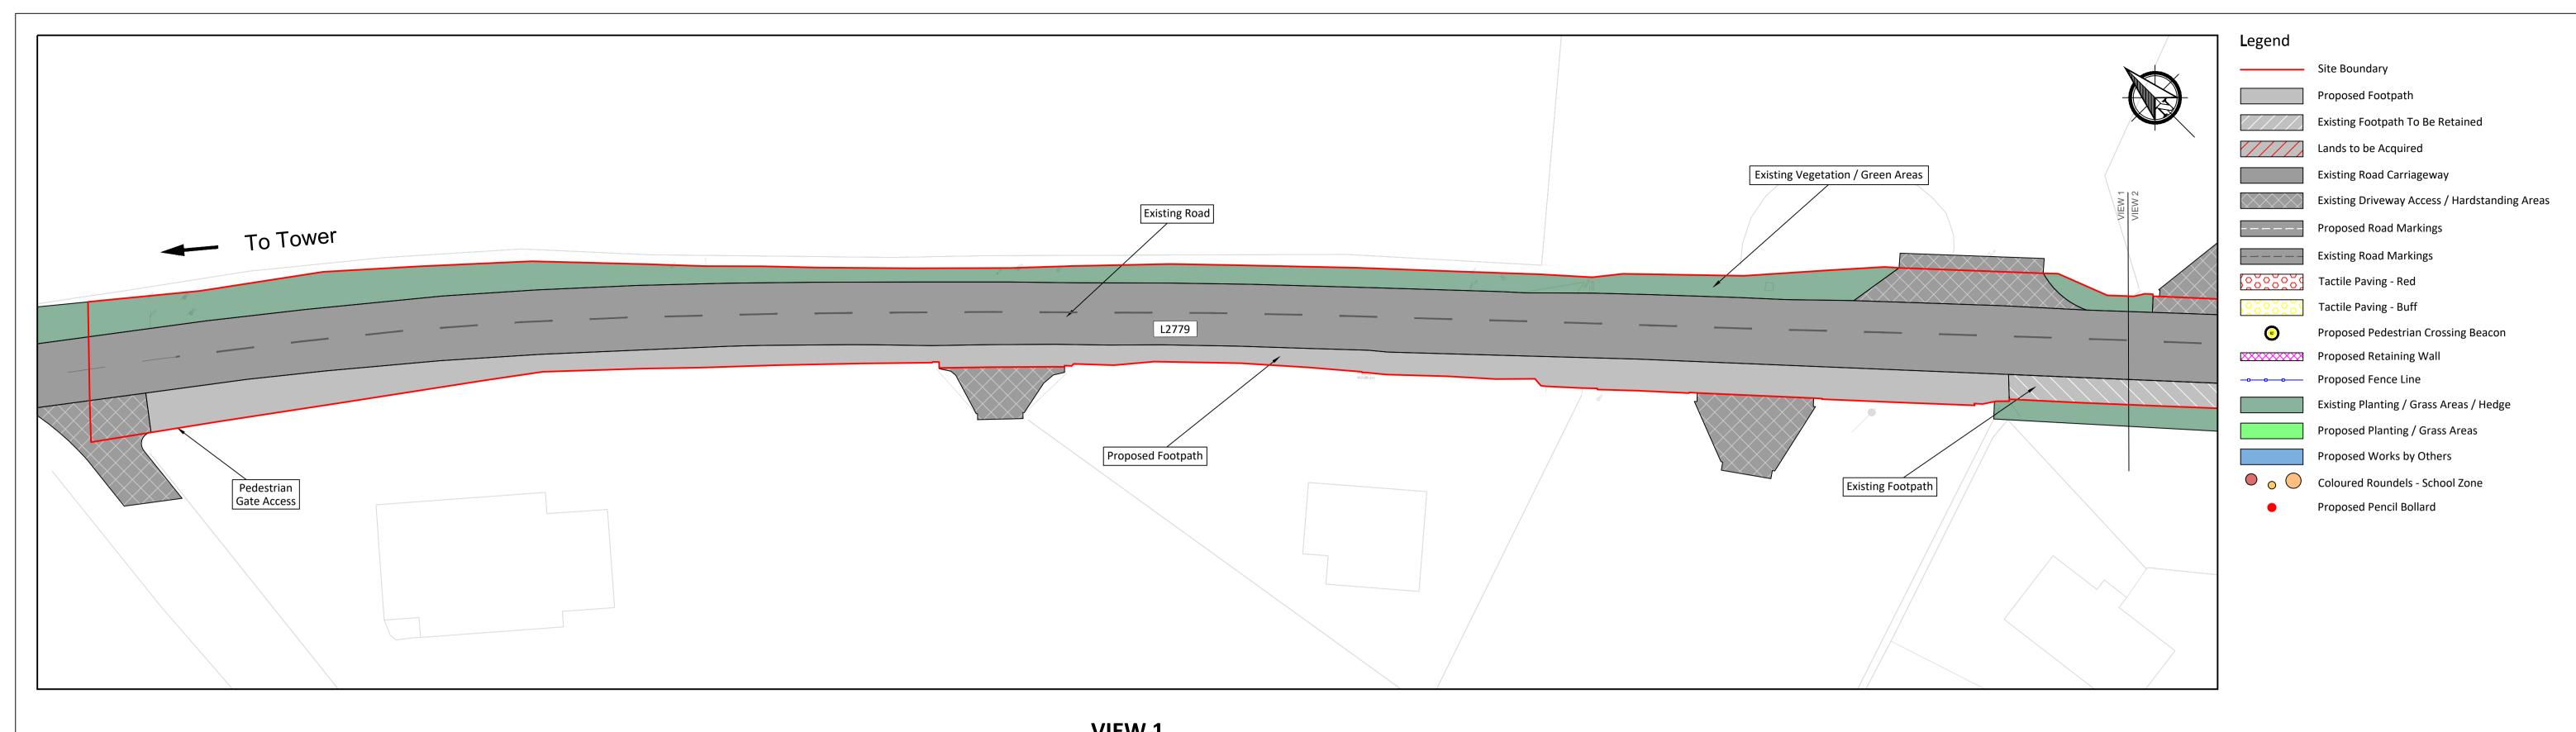

VIEW 1
Scale 1:250

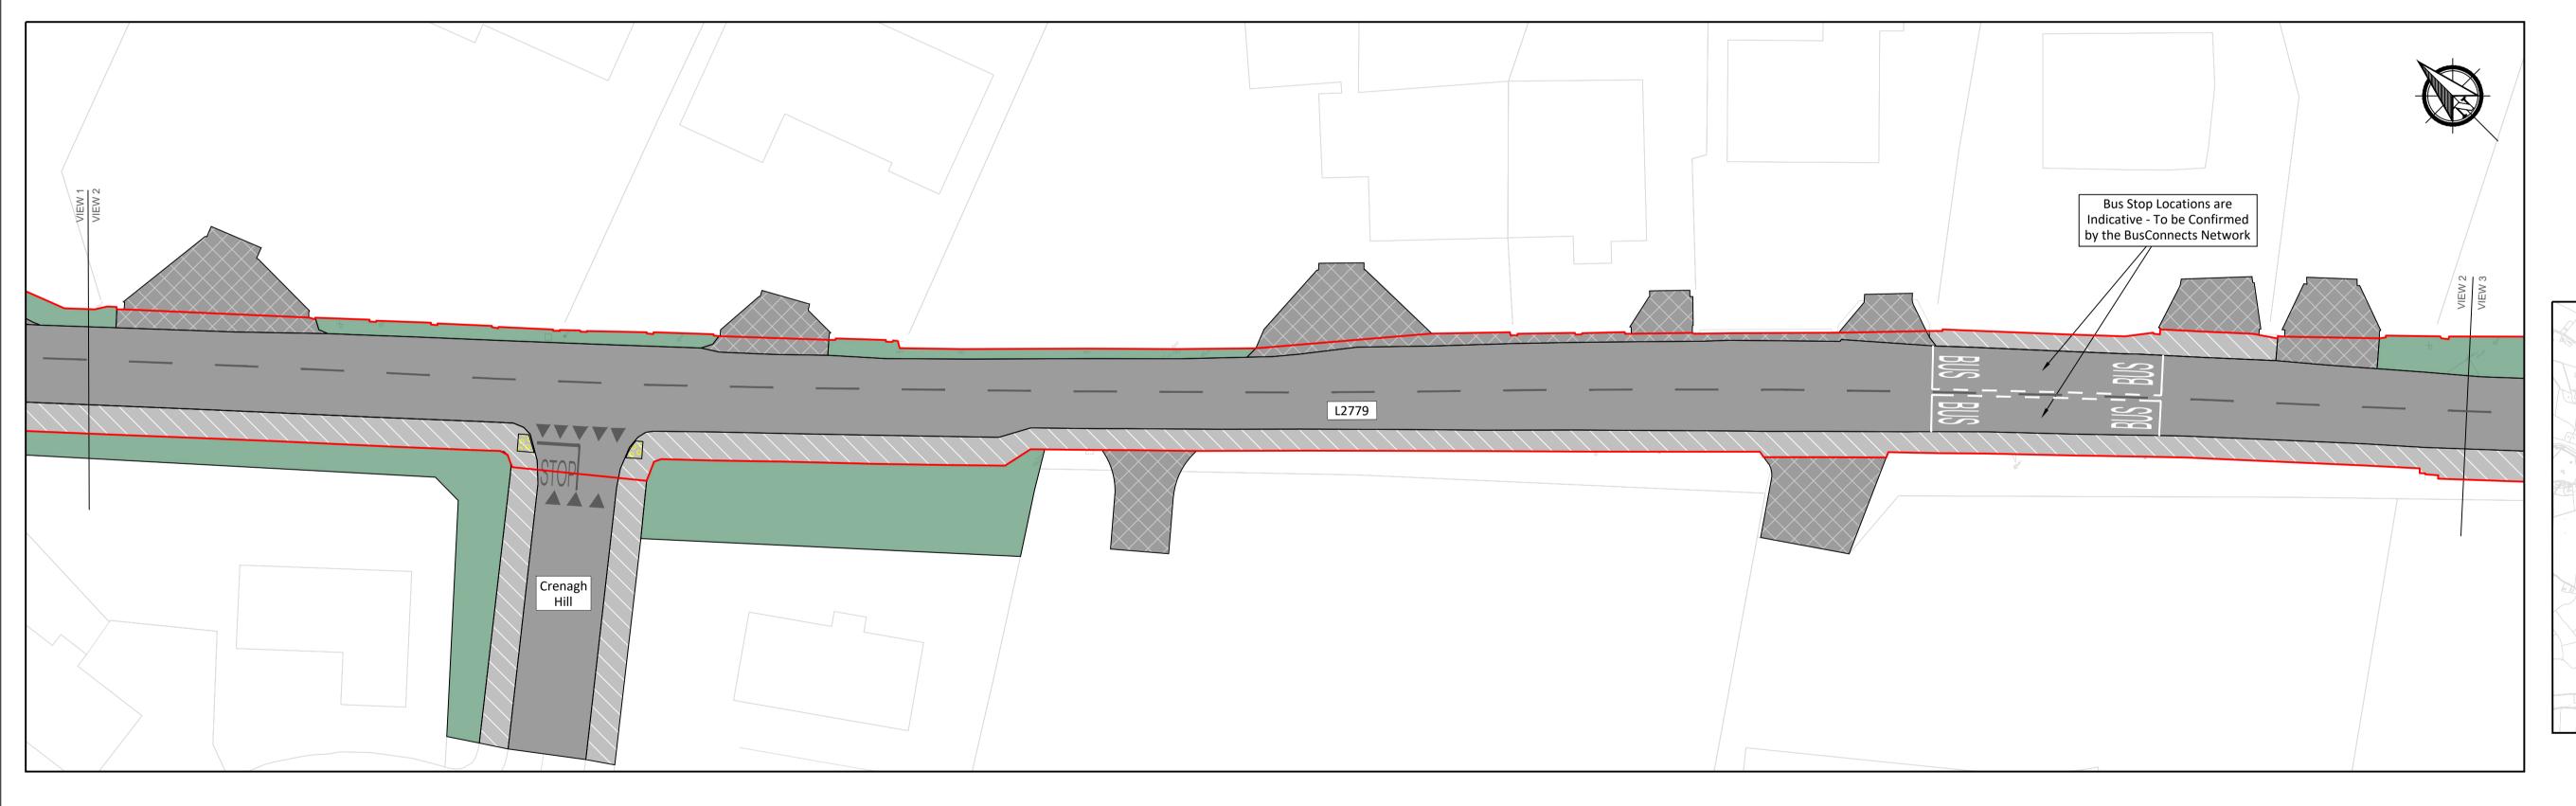

VIEW 2
Scale 1:250

©Ordnance Survey Ireland. All rights reserved. Licence number: CYAL50247147

Rev. Description App By Date

A ISSUED FOR SECTION 38 PLANNING GF 29.02.24

PROJECT	KERRY PIKE PEDESTRIAN IMPROVEMENT SCHEME	CLIENT	Comhairle Cathrach Chorcaí Cork City Council	
SHEET		Date 29.02.24	Project number P22-181	Scale (@ A1-) 1:250
	SECTION 38 PROPOSAL	Drawn by AQ	Drawing Number	
	SHEET 1 OF 8	Checked by	P22-181-0102-1004	4

O:\ACAD\2022\P22-181\P22-181-0102-1004

No part of this document may be reproduced or transmitted in any form or stored in any retrieval system of any nature without the written permission of Fehily Timoney & Company as copyright holder except as agreed for use on the project for which the document was originally issued. Do not scale. Use figured dimensions only. If in doubt - Ask!

FEHILY Cork | Dublin | Carlow www.fehilytimoney.ie

Wednesday 28 February 2024


KEY PLAN

Scale 1:25000

Scale 1:250



Scale 1:250

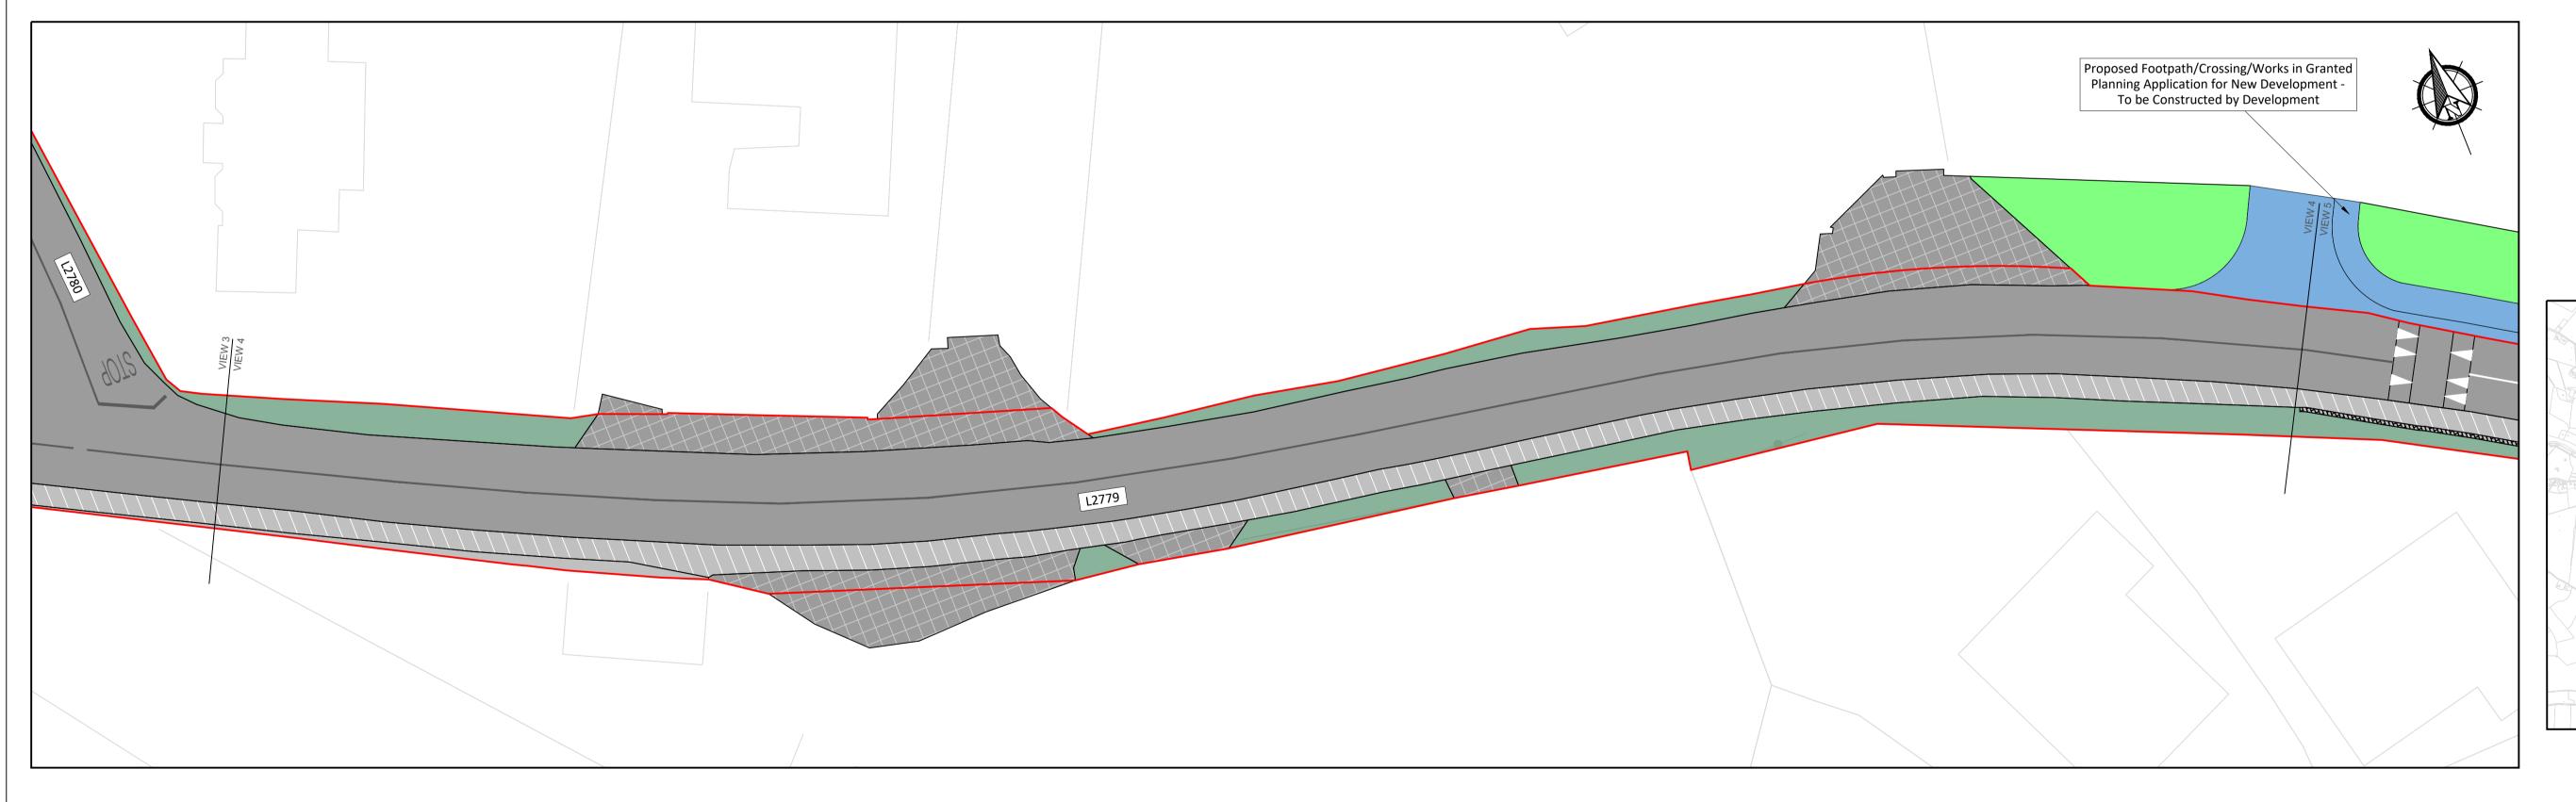

Scale 1:25000

Scale 1:250

VIEW 4

Scale 1:250


©Ordnance Survey Ireland. All rights reserved. Licence number: CYAL50247147

FEHILY Cork | Dublin | Carlow www.fehilytimoney.ie


No part of this document may be reproduced or transmitted in any form or stored in any retrieval system of any nature without the written permission of Fehily Timoney & Company as copyright holder except as agreed for use on the project for which the document was originally issued. Do not scale. Use figured dimensions only. If in doubt - Ask!

Rev.	Description	Арр Ву	Date
Α	ISSUED FOR SECTION 38 PLANNING	GF	29.02.2

KERRY PIKE PEDESTRIAN IMPROVEMENT SCHEME	CLIENT		Comhairle Cathrach Chorcaí Cork City Council		
SHEET CE CELONI 20 DDC CAL	Date	29.02.24	Project number P22-181	Scale (@ A1-) 1:250	
SECTION 38 PROPOSAL SHEET 2 OF 8	Drawn by	AQ	Drawing Number		Rev
SHELL ZOF 8	Checked by	PW	P22-181-0102-1005		A

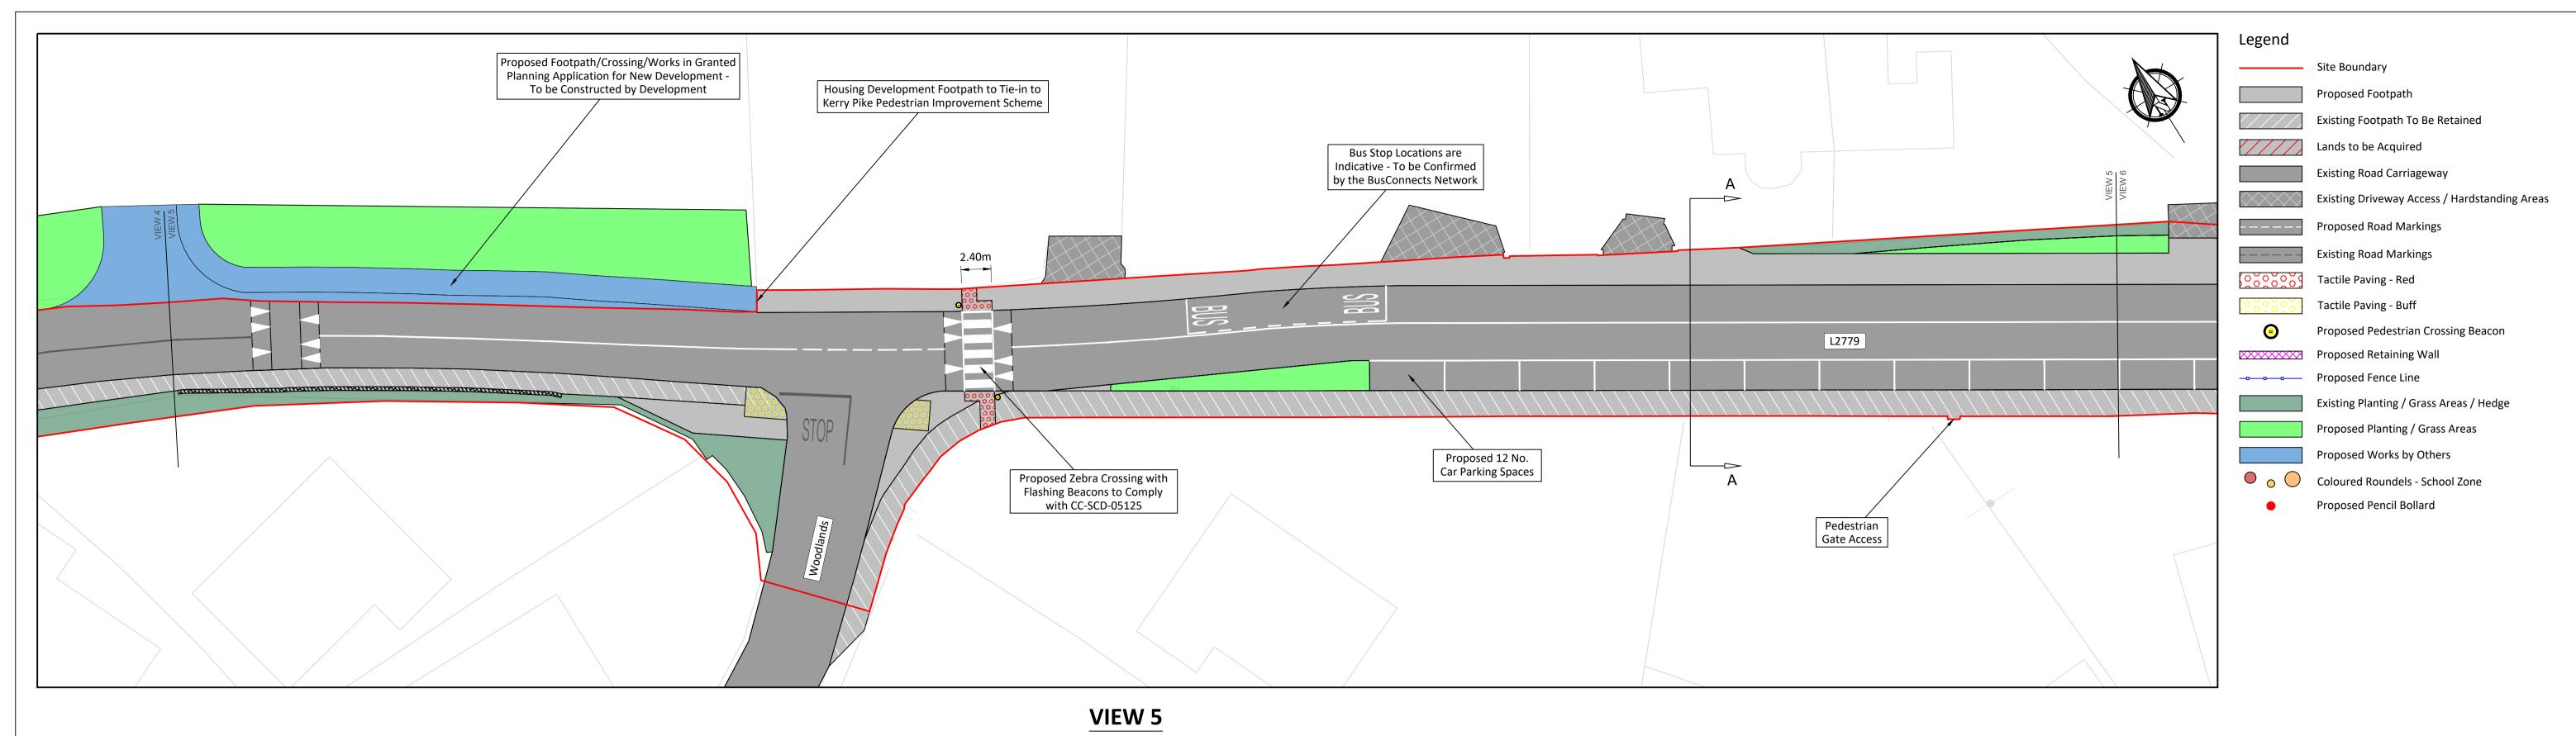

Scale 1:250

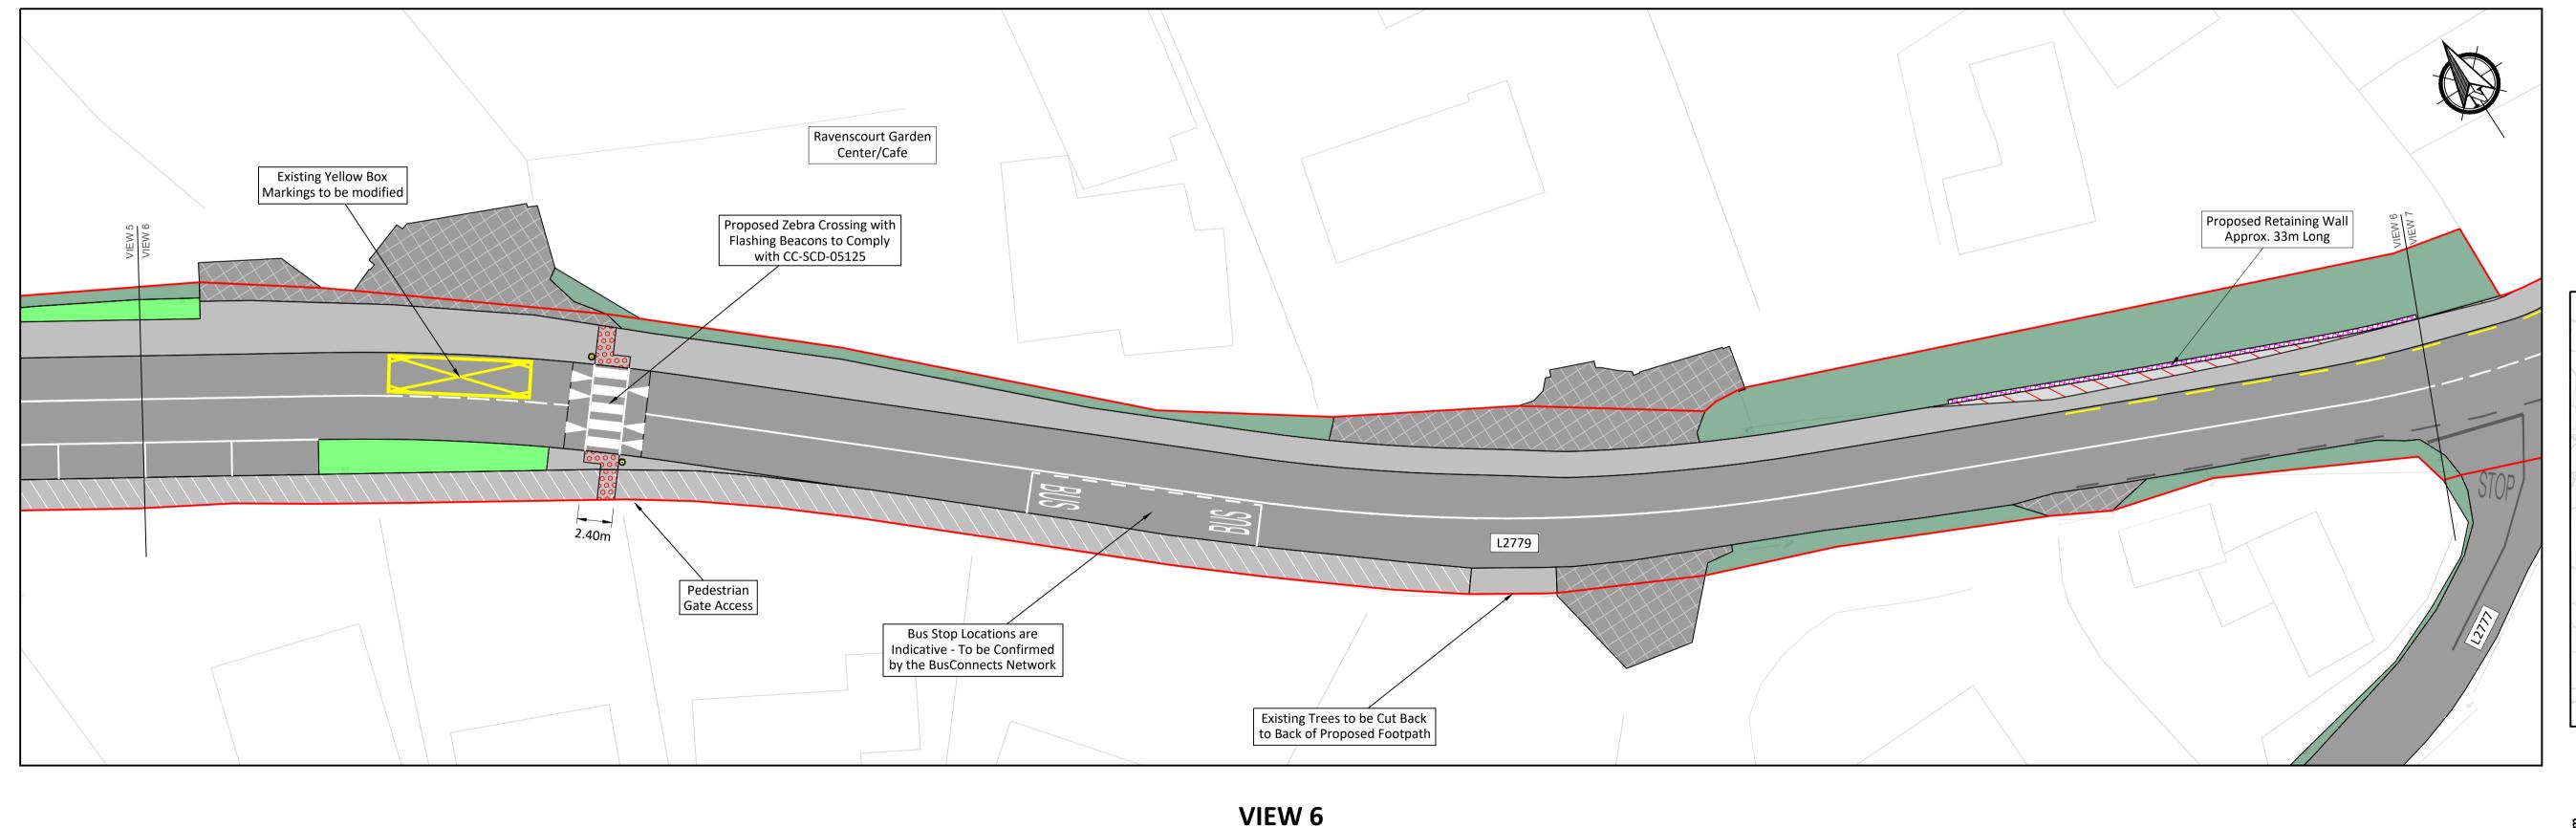

KEY PLAN

Scale 1:25000 Scale 1:250

©Ordnance Survey Ireland. All rights reserved. Licence number: CYAL50247147


FEHILY Cork | Dublin | Carlow TIMONEY www.fehilytimoney.ie

No part of this document may be reproduced or transmitted in any form or stored in any retrieval system of any nature without the written permission of Fehily Timoney & Company as copyright holder except as agreed for use on the project for which the document was originally issued. Do not scale. Use figured dimensions only. If in doubt - Ask!


Description	Арр Ву	Date
ISSUED FOR SECTION 38 PLANNING	GF	29.02.2

Scale 1:250

KERRY PIKE PEDESTRIAN IMPROVEMENT SCHEME	CLIENT		Comhairle Cathrach Chorcaí Cork City Council		
SHEET	Date	29.02.24	Project number P22-181	Scale (@ A1-) 1:250	
SECTION 38 PROPOSAL SHEET 3 OF 8	Drawn by	AQ	Drawing Number		Rev
SHEET S OF 8	Checked by	PW	P22-181-0102-1006		A
	O:\ACAD\2022\P22	2-181\P22-181-0102-:	1006	<u> </u>	

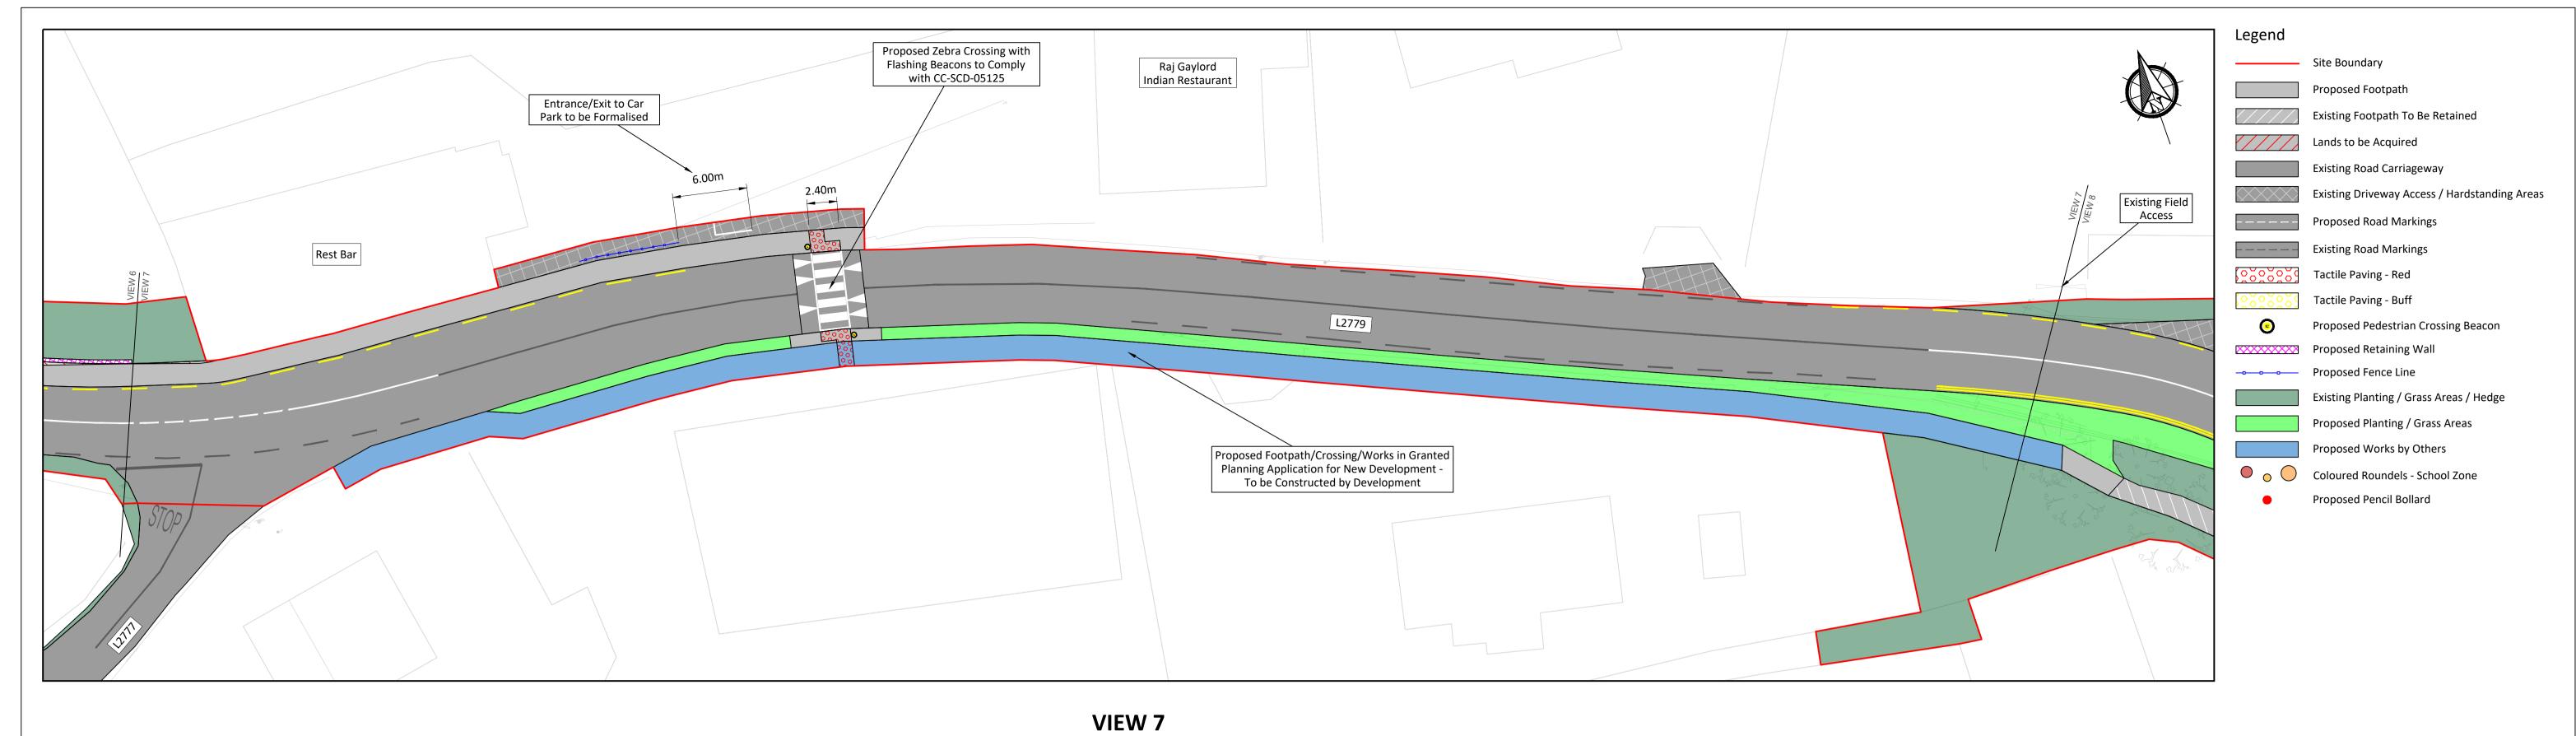

Scale 1:250

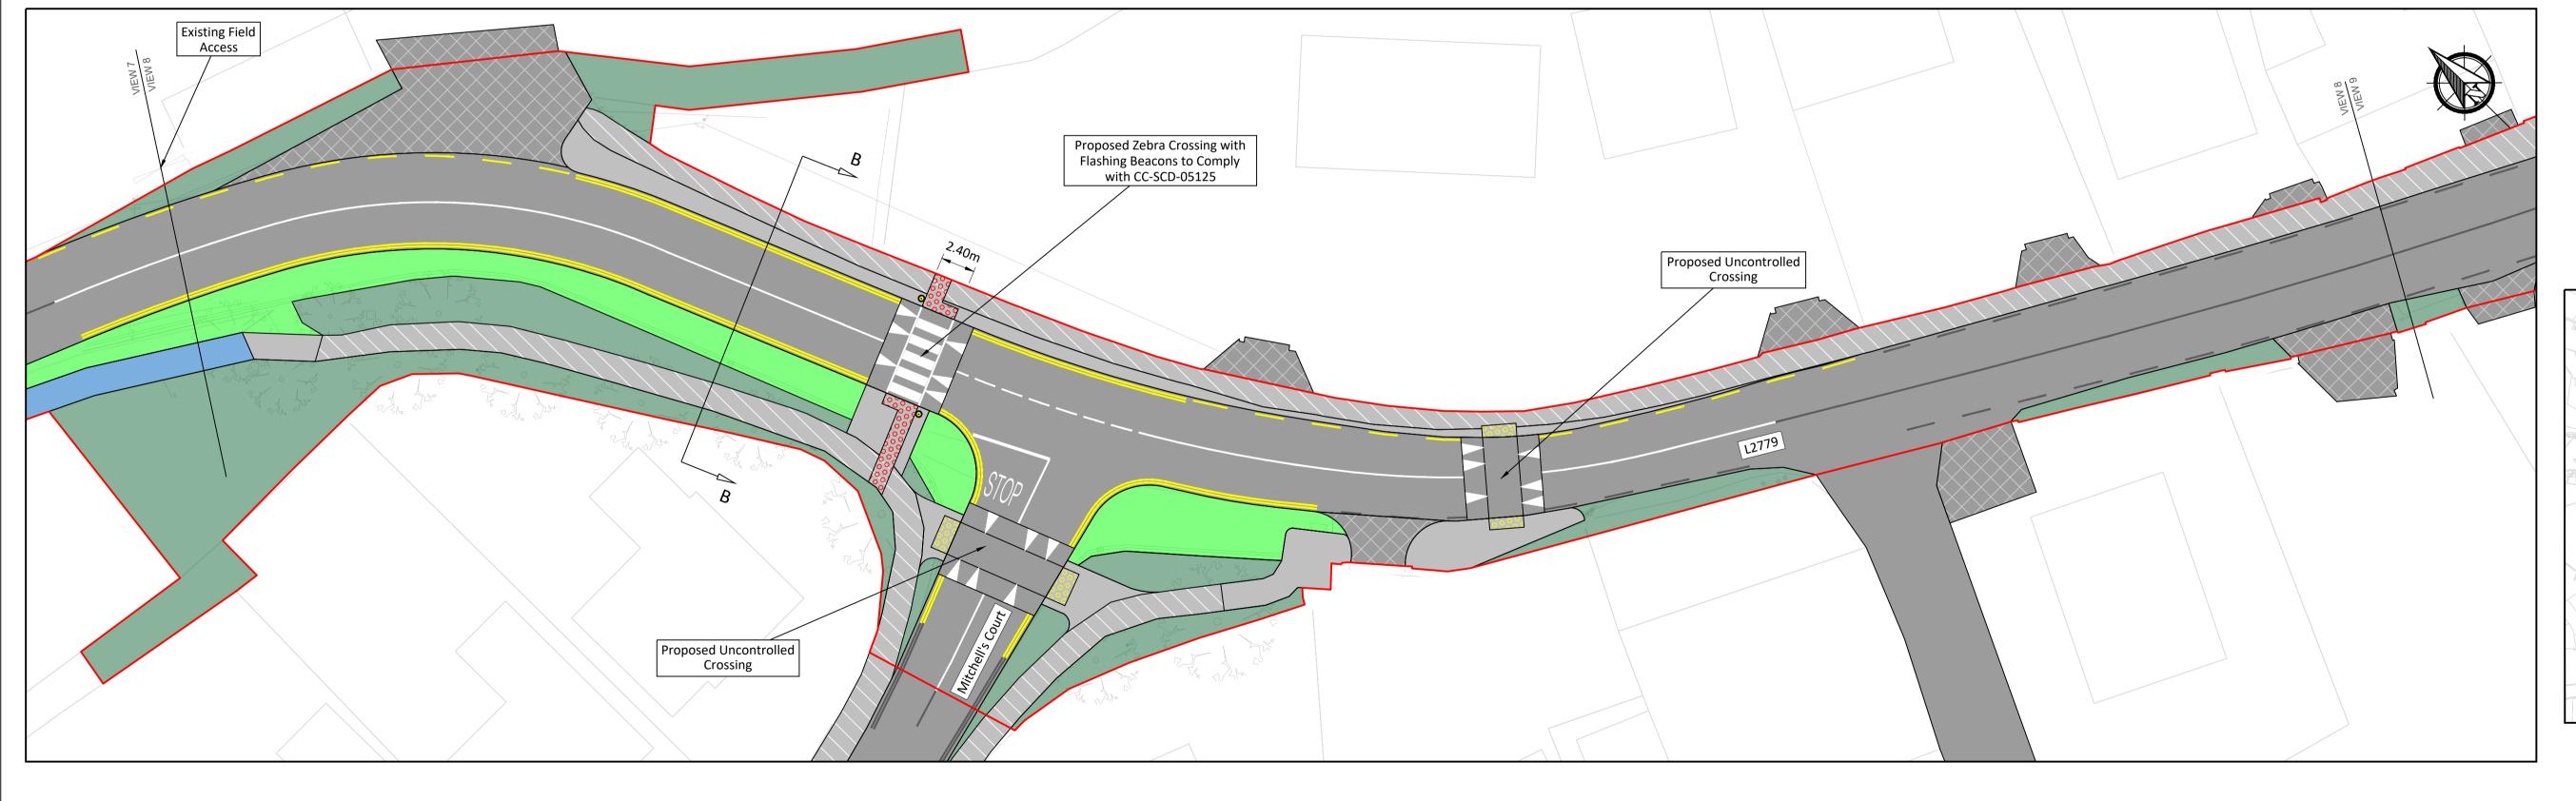

Scale 1:25000

Scale 1:250

VIEW 8

Scale 1:250


©Ordnance Survey Ireland. All rights reserved. Licence number: CYAL50247147

FEHILY Cork | Dublin | Carlow www.fehilytimoney.ie


No part of this document may be reproduced or transmitted in any form or stored in any retrieval system of any nature without the written permission of Fehily Timoney & Company as copyright holder except as agreed for use on the project for which the document was originally issued. Do not scale. Use figured dimensions only. If in doubt - Ask!

Rev.	Description	Арр Ву	Date
Α	ISSUED FOR SECTION 38 PLANNING	GF	29.02.24

-	KERRY PIKE PEDESTRIAN IMPROVEMENT SCHEME	CLIENT		Comhairle Cathrach Chorcaí Cork City Council		
	SHEET	Date	29.02.24	Project number P22-181	Scale (@ A1-) 1:250	
	SECTION 38 PROPOSAL SHEET 4 OF 8	Drawn by	AQ	Drawing Number		Rev
	SHEET 4 OF 8	Checked by	PW	P22-181-0102-1007		Α
_		O:\ACAD\2022\P22-	-181\P22-181-0102-1	007		_

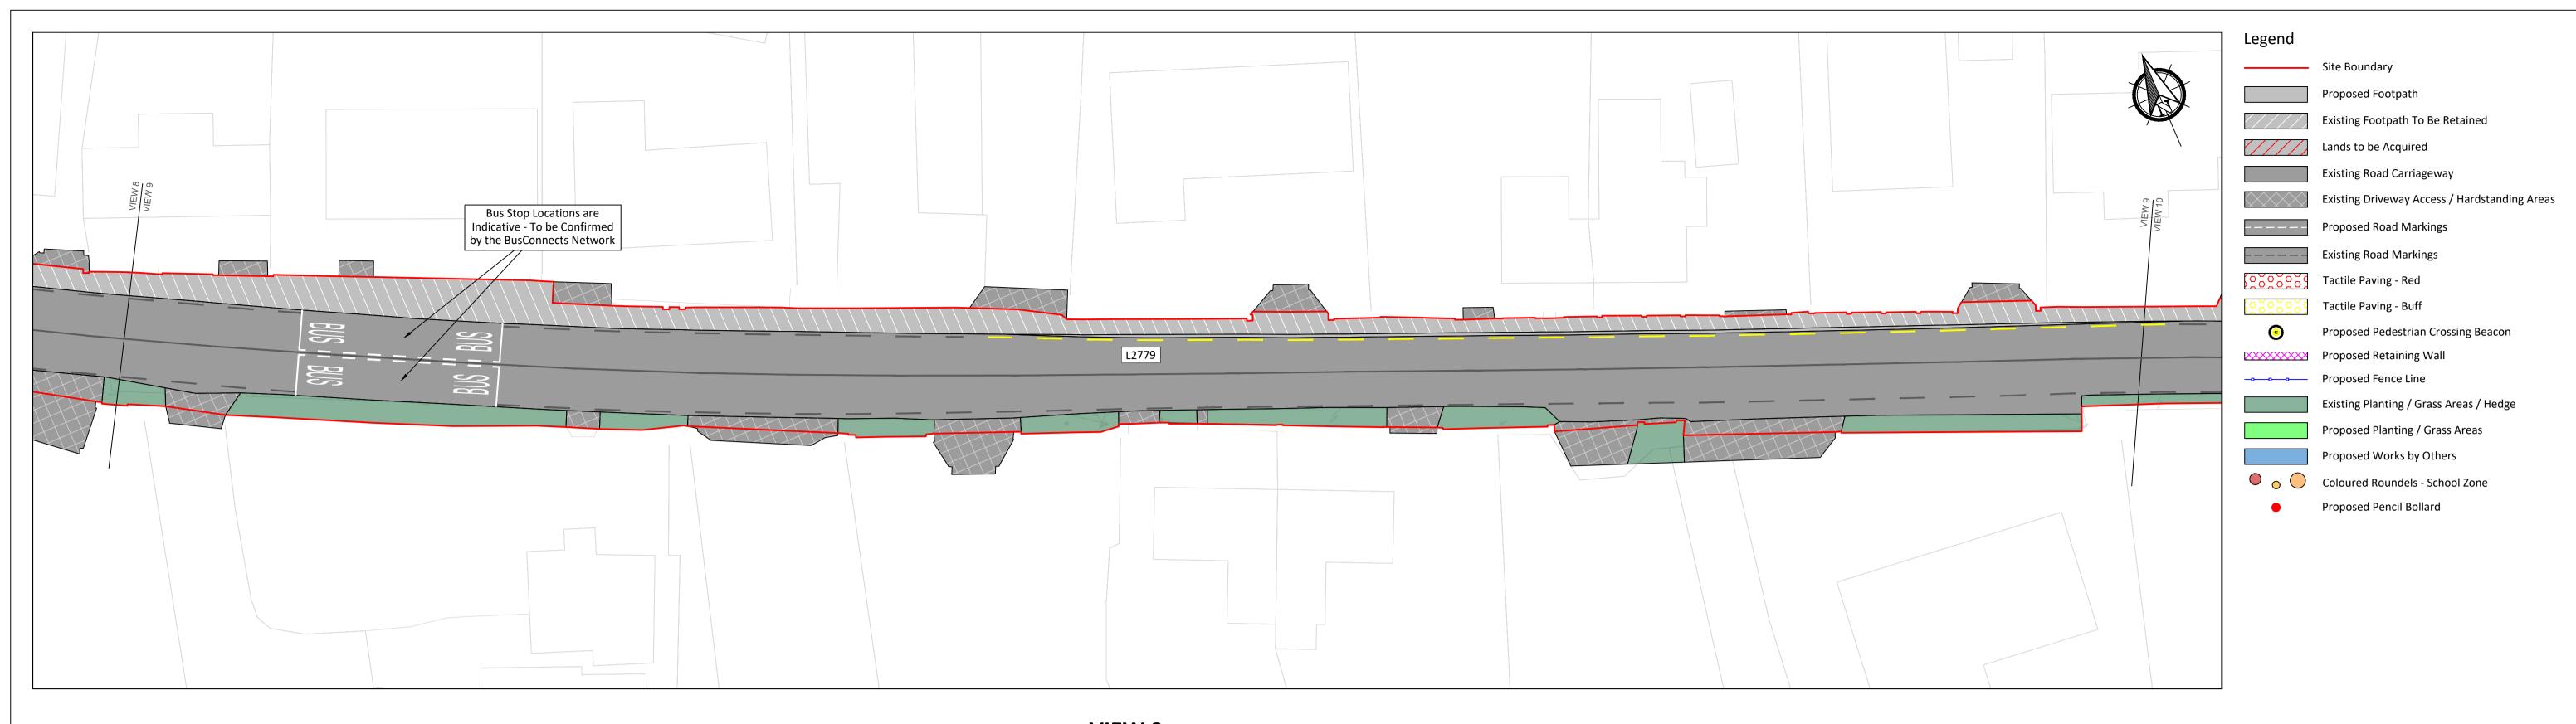

VIEW 9
Scale 1:250

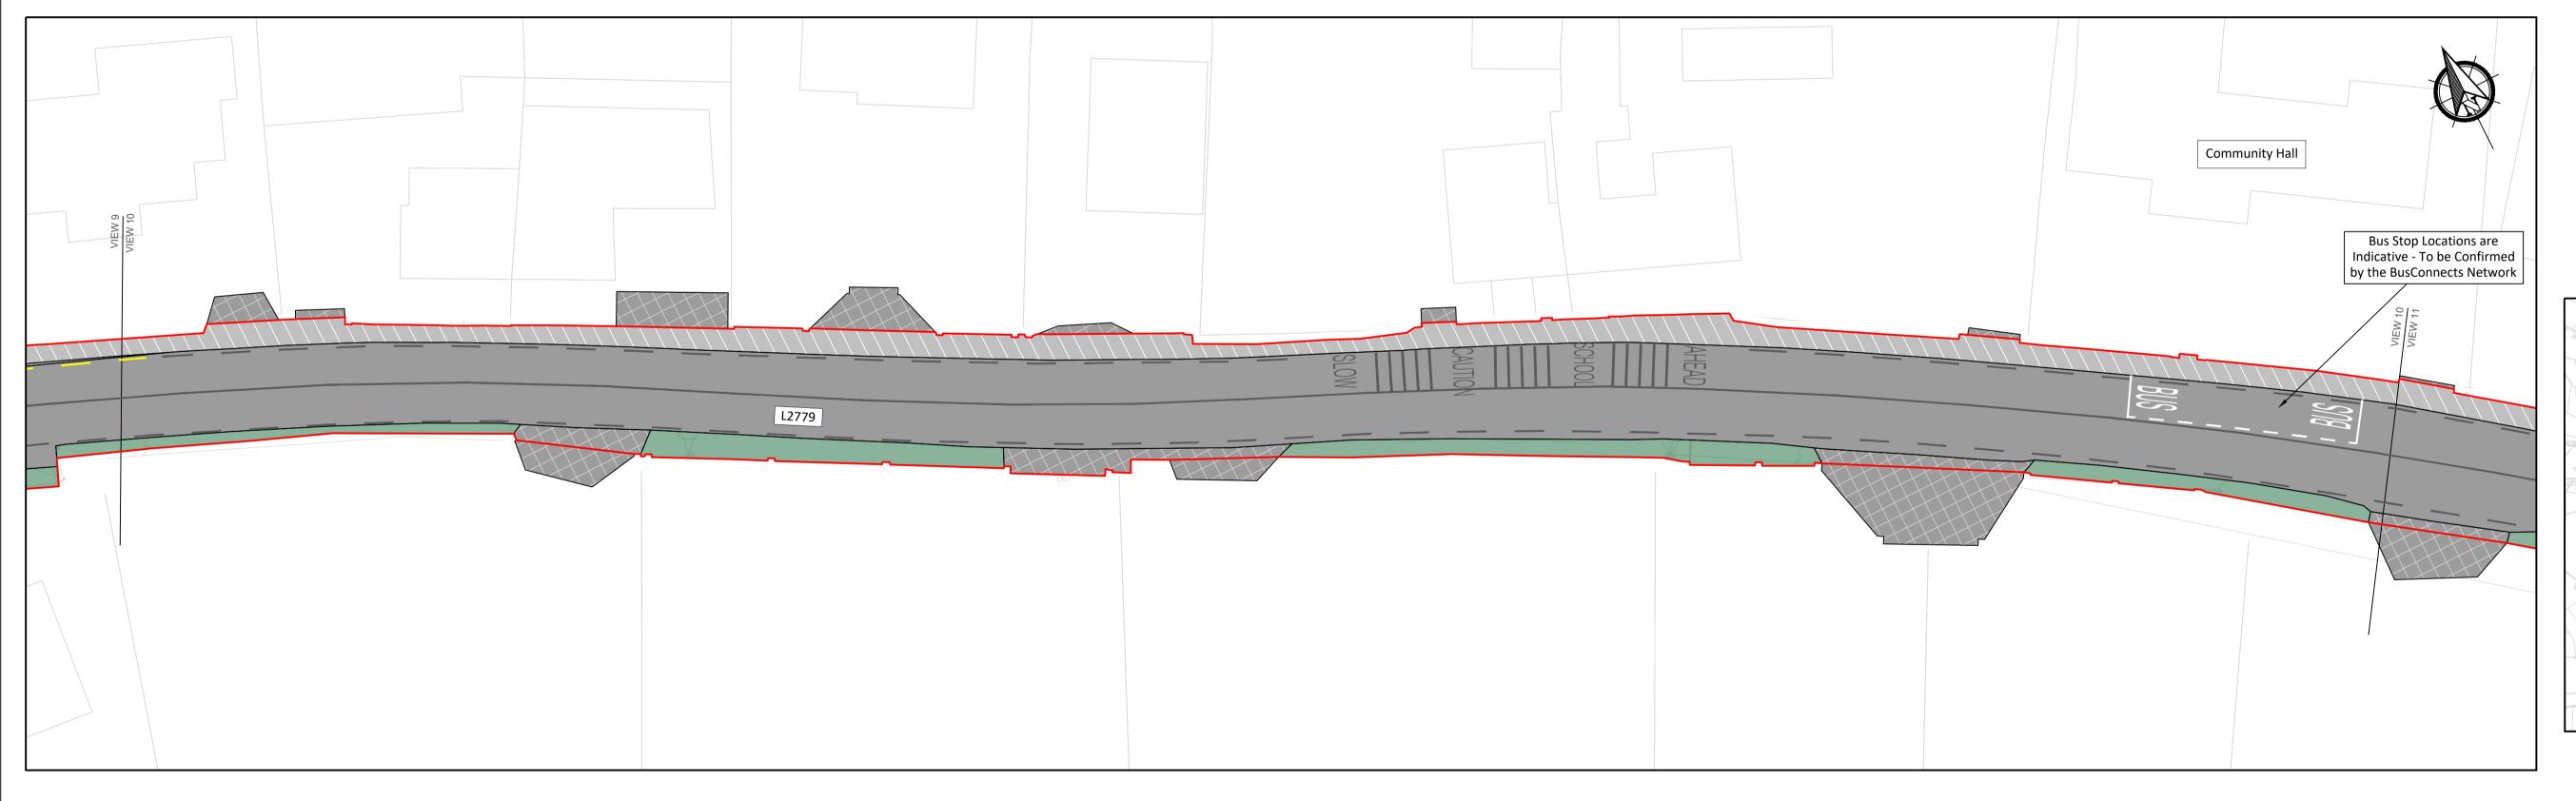

Scale 1:25000

Scale 1:250

VIEW 10

Scale 1:250


©Ordnance Survey Ireland. All rights reserved. Licence number: CYAL50247147

FEHILY Cork | Dublin | Carlow TIMONEY www.fehilytimoney.ie


No part of this document may be reproduced or transmitted in any form or stored in any retrieval system of any nature without the written permission of Fehily Timoney & Company as copyright holder except as agreed for use on the project for which the document was originally issued. Do not scale. Use figured dimensions only. If in doubt - Ask!

Rev.	Description	Арр Ву	Date
Α	ISSUED FOR SECTION 38 PLANNING	GF	29.02.2

KERRY PIKE PEDESTRIAN IMPROVEMENT SCHEME	CLIENT		Comhairle Cathrach Chorcaí Cork City Council		
SHEET CECTION 30 DDCCAL	Date	29.02.24	Project number P22-181	Scale (@ A1-) 1:250	
SECTION 38 PROPOSAL SHEET 5 OF 8	Drawn by	AQ	Drawing Number		Rev
SHEET S OF 8	Checked by	PW	P22-181-0102-1008		A

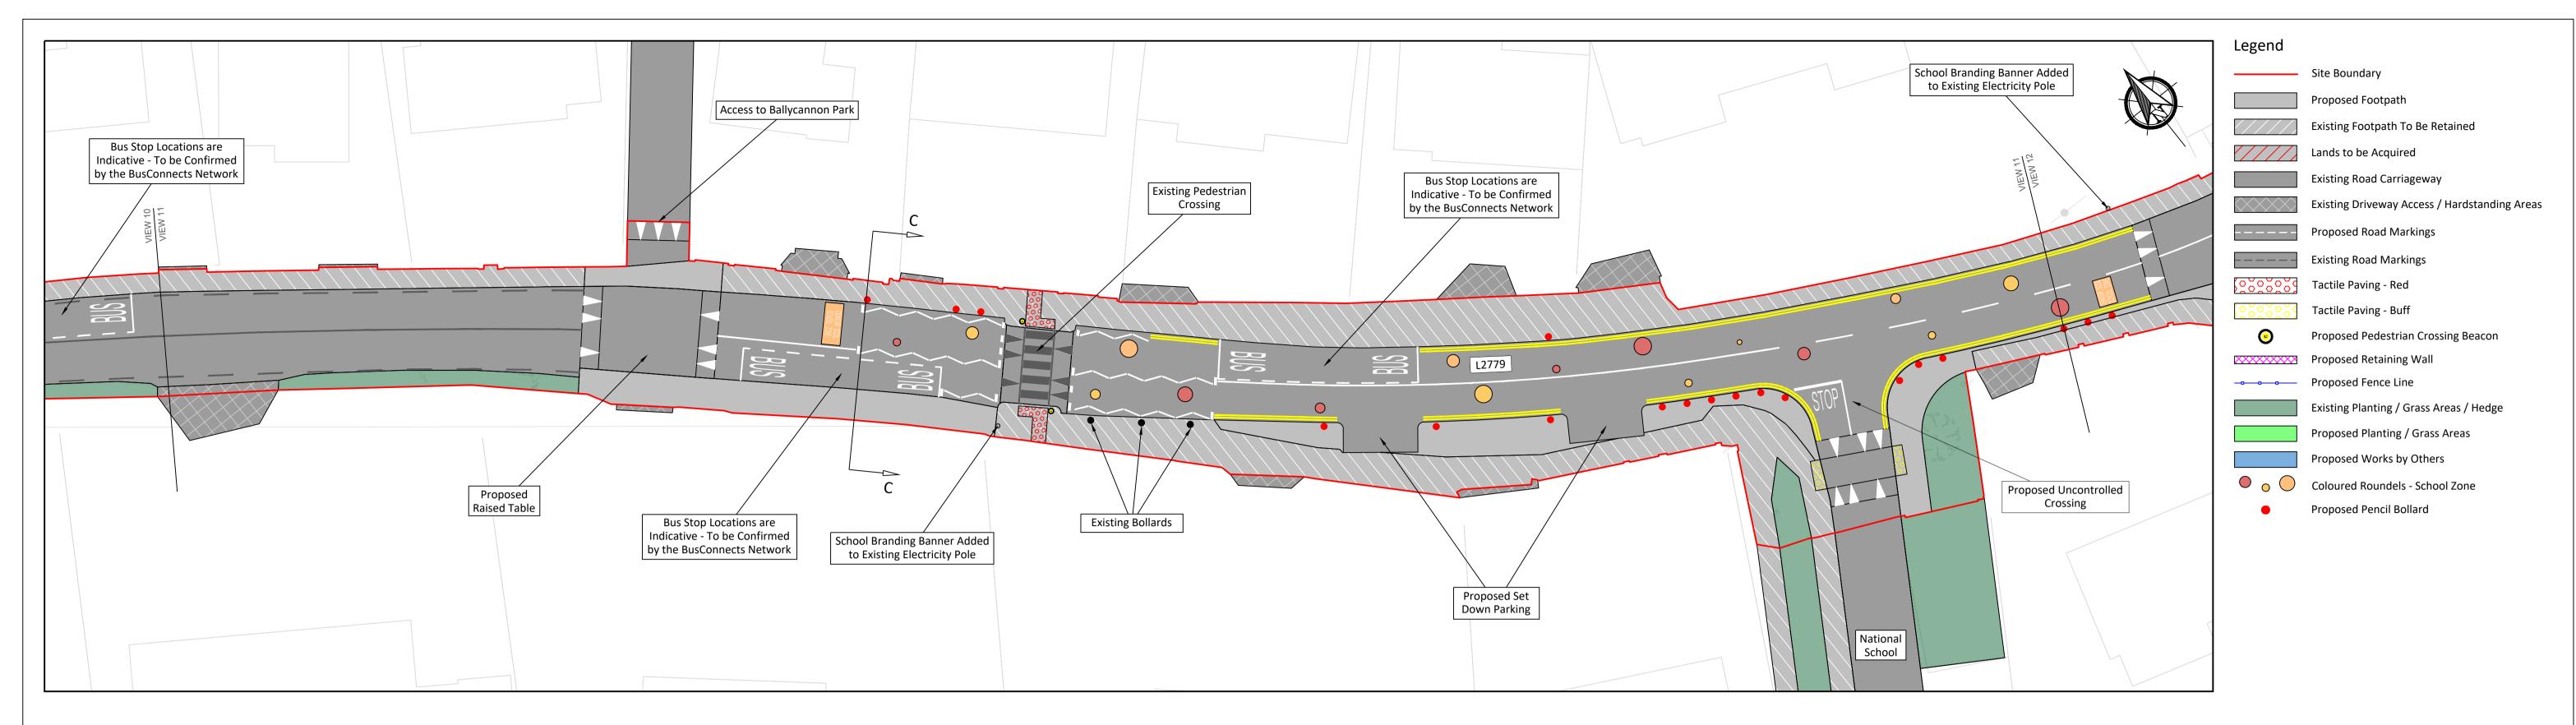

VIEW 11
Scale 1:250

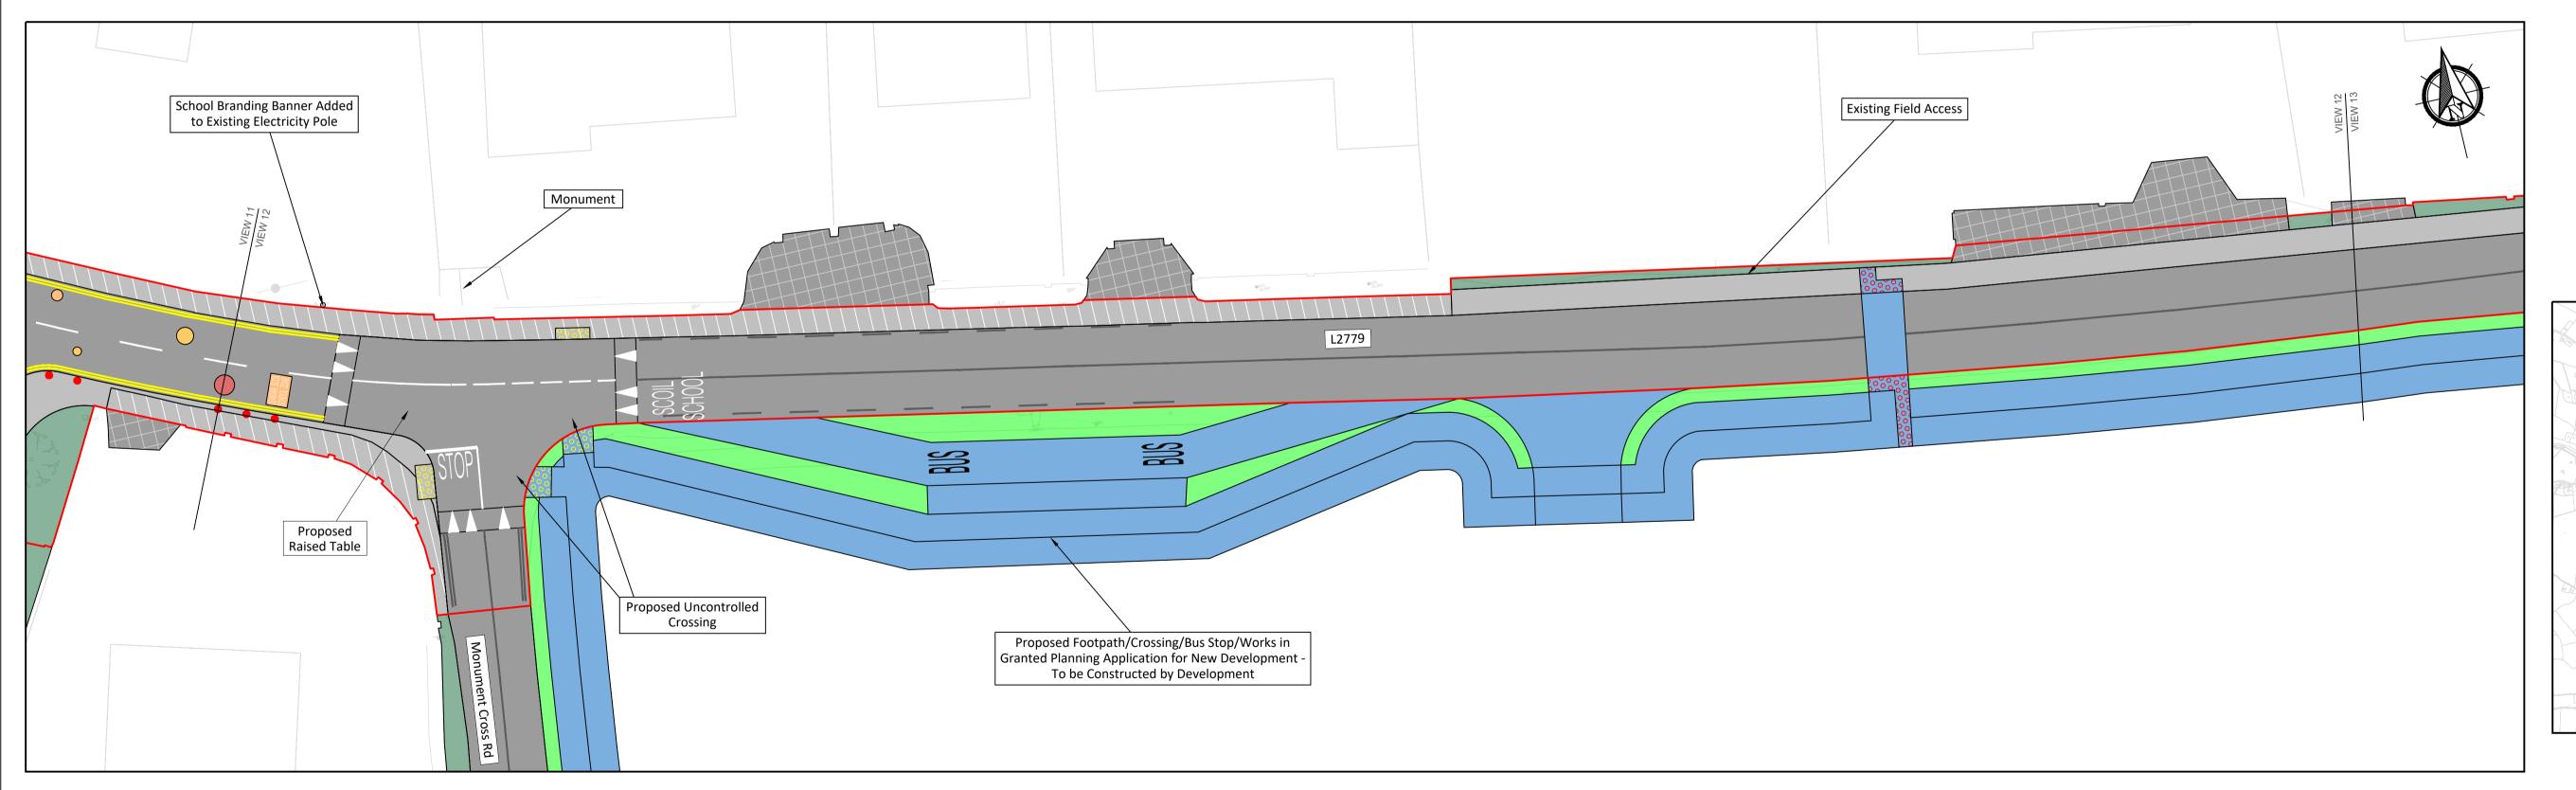

VEV DI ANI

KEY PLAN

©Ordnance Survey Ireland. All rights reserved. Licence number: CYAL50247147

FEHILY Cork | Dublin | Carlow www.fehilytimoney.ie


No part of this document may be reproduced or transmitted in any form or stored in any retrieval system of any nature without the written permission of Fehily Timoney & Company as copyright holder except as agreed for use on the project for which the document was originally issued. Do not scale. Use figured dimensions only. If in doubt - Ask!

Rev.	Description	Арр Ву	Date
Α	ISSUED FOR SECTION 38 PLANNING	GF	29.02.24


VIEW 12

Scale 1:250

KERRY PIKE PEDESTRIAN IMPROVEMENT SCHEME		Comhairle Cathrach Chorcaí Cork City Council				
SHEET CECTION 30 DDODGCAL	Date	29.02.24	Project number P22-181	Scale (@ A1-) 1:250		
SECTION 38 PROPOSAL SHEET 6 OF 8	Drawn by	AQ	Drawing Number		Rev	
SHELL OUF 8	Checked by	PW	P22-181-0102-1009		Α	

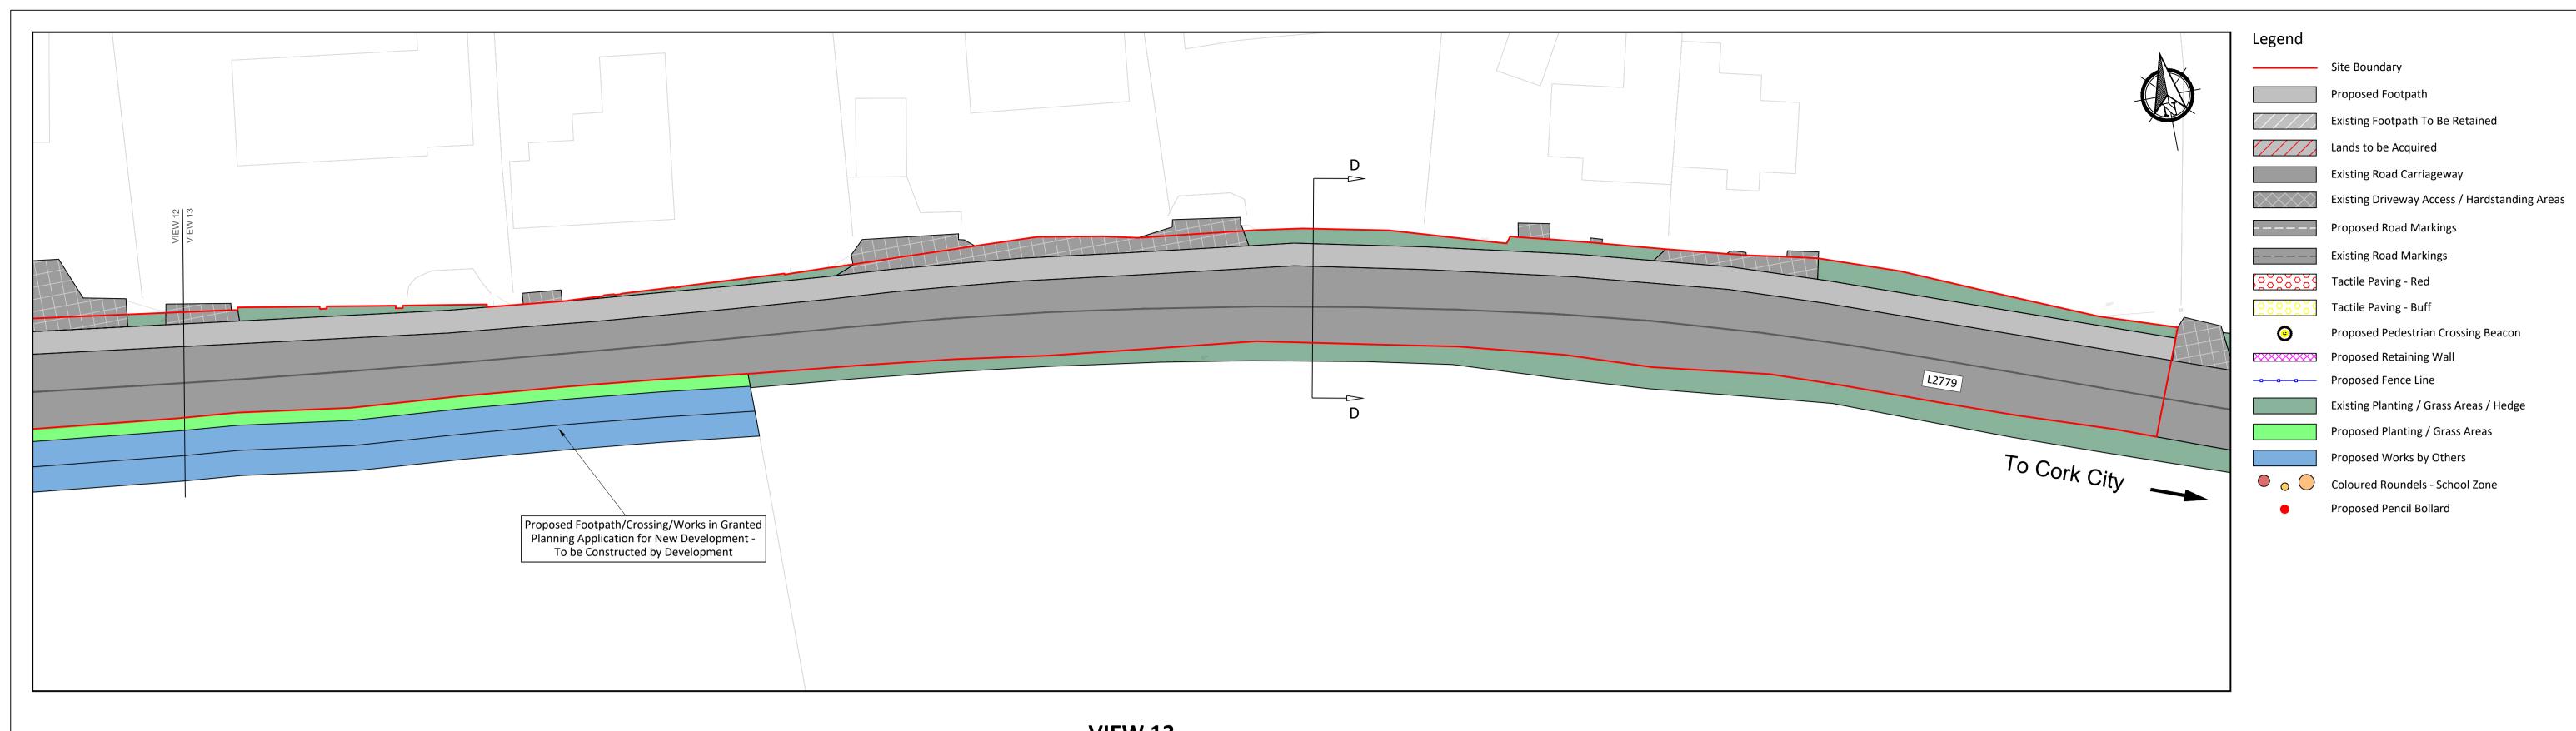

VIEW 13 Scale 1:250

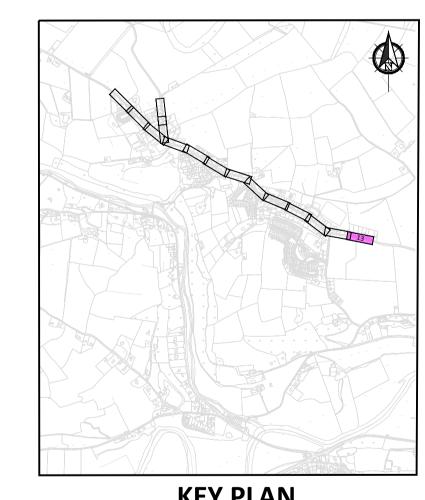

KEY PLAN Scale 1:25000 Scale 1:250

©Ordnance Survey Ireland. All rights reserved. Licence number: CYAL50247147




issued. Do not scale. Use figured dimensions only. If in doubt - Ask!

No part of this document may be reproduced or transmitted in any form or stored in any retrieval system of any nature without the written permission of Fehily Timoney & Company as copyright holder except as agreed for use on the project for which the document was originally

Rev.	Description	Арр Ву	Date
Α	ISSUED FOR SECTION 38 PLANNING	GF	29.02.24

SIILLI / O		Checked by	PW	P22-181-0102-1010		Α
SECTION 38 PROSHEET 7 O		Drawn by	AQ	Drawing Number		Rev
SHEET CECTION 30 DD		Date	29.02.24	Project number P22-181	Scale (@ A1-) 1:250	
KERRY PIKE PED IMPROVEMENT	ESTRIAN	CLIENT		Comhairle Cathrach Chorcaí Cork City Council		

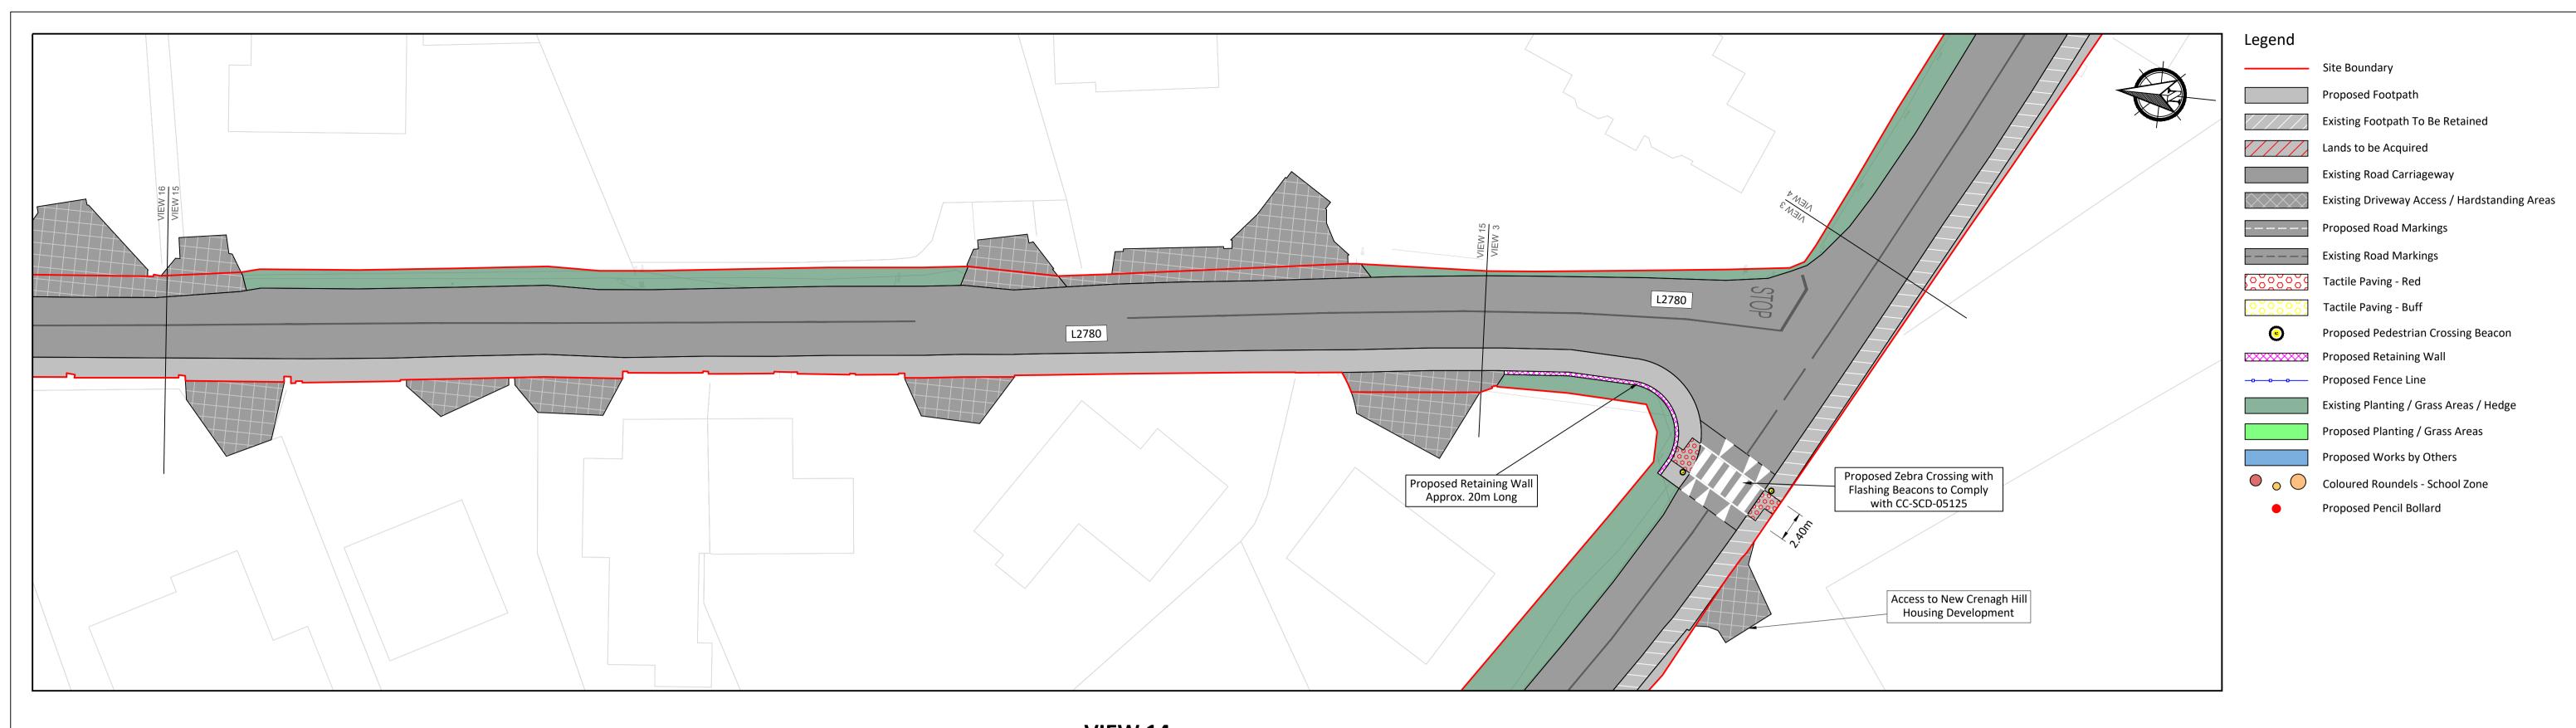

VIEW 14
Scale 1:250



Scale 1:25000

Scale 1:250

VIEW 15
Scale 1:250


©Ordnance Survey Ireland. All rights reserved. Licence number: CYAL50247147

FEHILY Cork | Dublin | Carlow www.fehilytimoney.ie

No part of this document may be reproduced or transmitted in any form or stored in any retrieval system of any nature without the writter	1
permission of Fehily Timoney & Company as copyright holder except as agreed for use on the project for which the document was originally	/
issued. Do not scale. Use figured dimensions only. If in doubt - Ask!	


Rev.	Description	Арр Ву	Date
Α	ISSUED FOR SECTION 38 PLANNING	GF	29.02.2

KERRY PIKE PEDESTRIAN IMPROVEMENT SCHEME	CLIENT		Comhairle Cathrach Chorcaí Cork City Council		
SHEET CECTION 30 DDCCAL	Date	29.02.24	Project number P22-181	Scale (@ A1-) 1:250	
SECTION 38 PROPOSAL SHEET 8 OF 8	Drawn by	AQ	Drawing Number		Rev
SHEET OUF O	Checked by	PW	P22-181-0102-1011		A

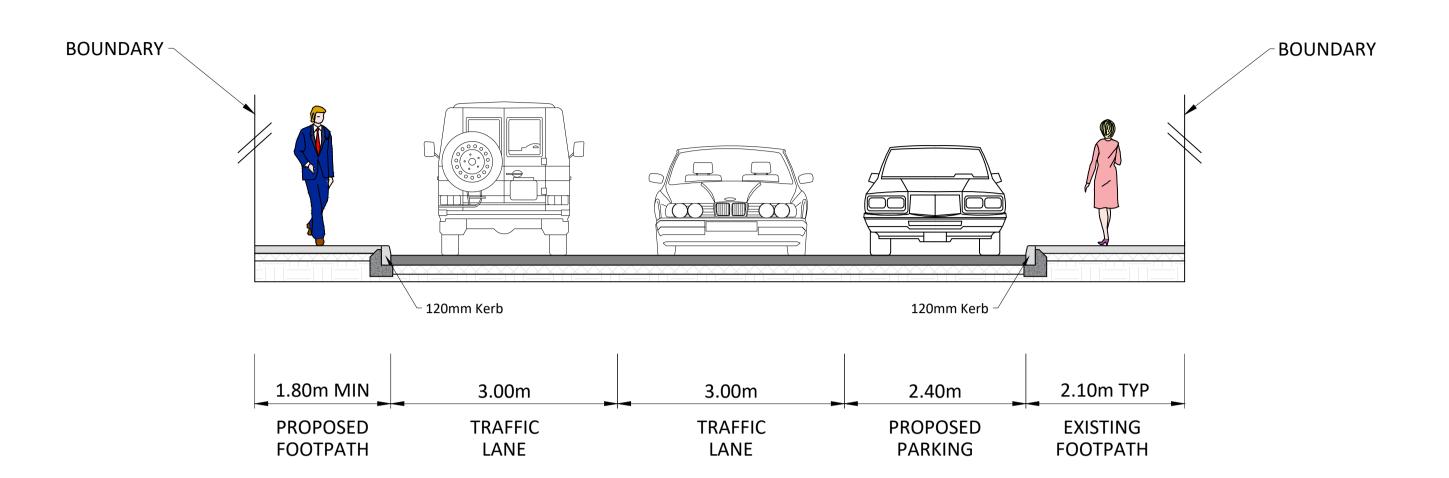


TYPICAL CROSS SECTION A-A EAST OF WOODLANDS

Scale 1:50

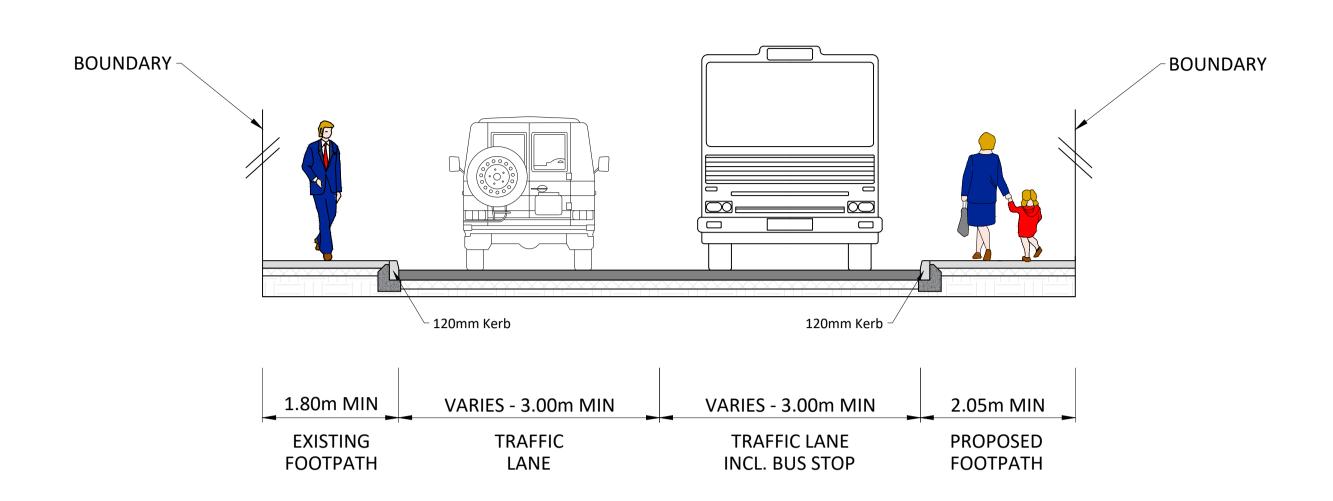


TYPICAL CROSS SECTION C-C WEST OF NATIONAL SCHOOL

Scale 1:50

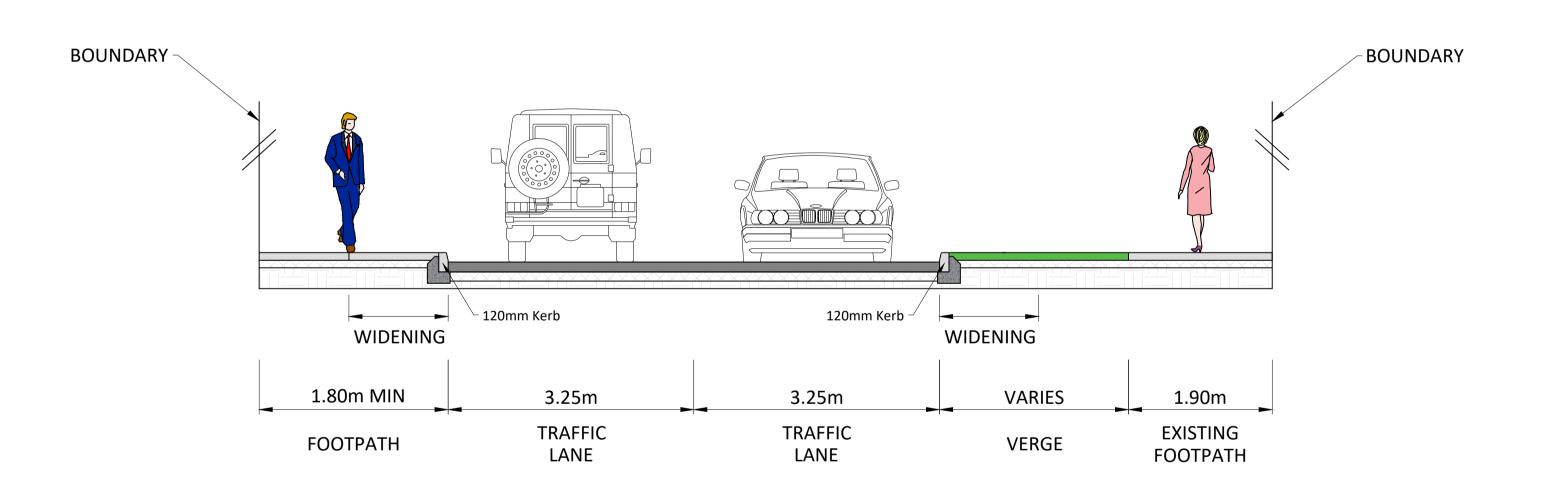


TYPICAL CROSS SECTION B-B WEST OF MITCHELLS COURT

Scale 1:50

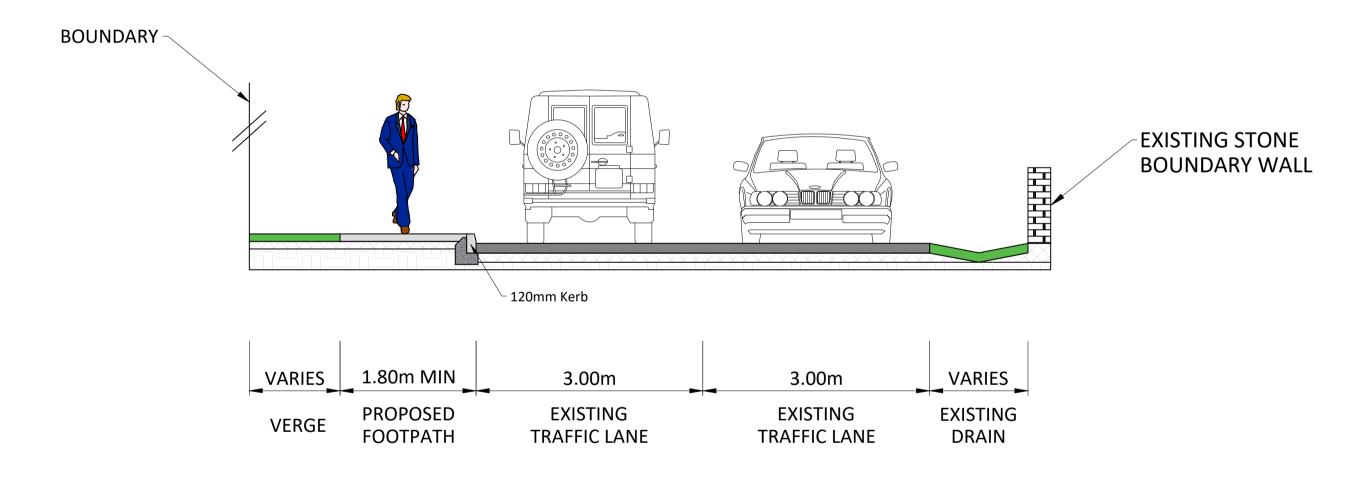

TYPICAL CROSS SECTION D-D EAST OF MONUMENT CROSS ROAD

 Scale 1:50





Rev.	Description	Арр Ву	Date
Α	ISSUED FOR SECTION 38 PLANNING	GF	29.02.24

PROJECT	CLIENT	
KERRY PIKE PEDESTRIAN		
IMPROVEMENT SCHEME	Comhairle Cathrach Chorcaí	
	Cork City Council	
SHEET	Date 29.02.24 Project number P22-181 Scale (@ A1-1:50	
TYPICAL CROSS SECTIONS	Drawn by AQ Drawing Number	Rev
	Checked by PW P22-181-0102-1012	A
	O:\ACAD\2022\P22-181\P22-181-0102-1012	